



INDEX OF PLANS

SHEET No.	DESCRIPTION
1	TITLE AND LOCATION MAP
2-3	TYPICAL CROSS SECTIONS
4-5	CONSTRUCTION DETAILS
6	CONSTRUCTION AREA SIGNS
7	PAVEMENT DELINEATION QUANTITIES
8-9	SIGN DETAILS & QUANTITIES
10	SUMMARY OF QUANTITIES
11-12	ELECTRICAL PLANS
13-24	REVISED STANDARD PLANS

THE STANDARD PLANS LIST APPLICABLE TO THIS CONTRACT IS INCLUDED IN THE NOTICE TO BIDDERS AND SPECIAL PROVISIONS BOOK.

STATE OF CALIFORNIA ACSTP-P004(150)E
DEPARTMENT OF TRANSPORTATION
PROJECT PLANS FOR CONSTRUCTION ON
STATE HIGHWAY
IN SAN JOAQUIN COUNTY
NEAR HOLT AT VARIOUS LOCATIONS
FROM OLD RIVER BRIDGE
TO 0.3 MILE WEST OF WHISKEY SLOUGH ROAD

TO BE SUPPLEMENTED BY STANDARD PLANS DATED 2010

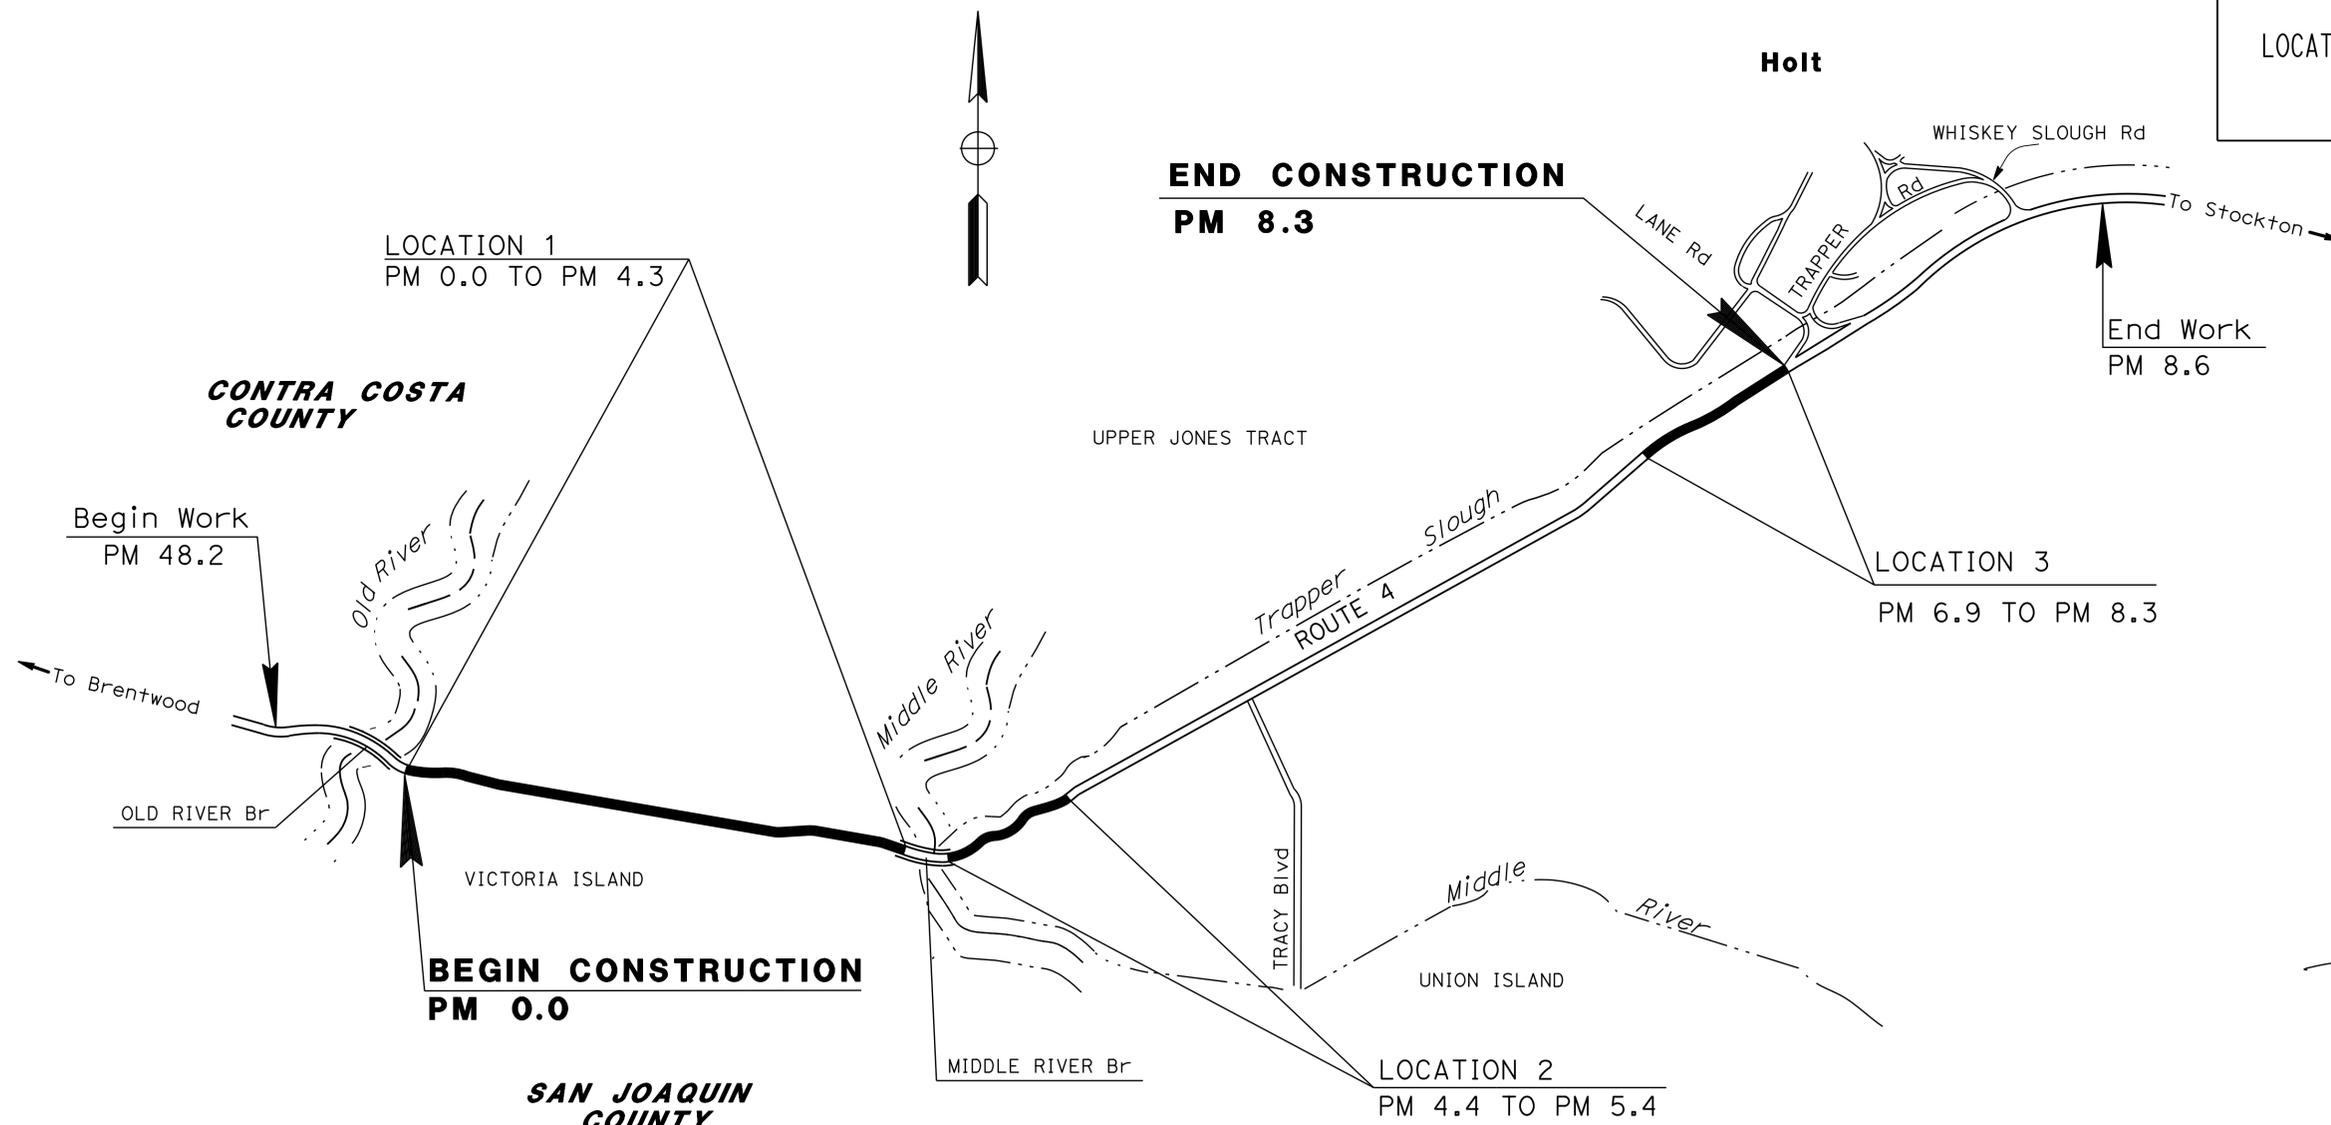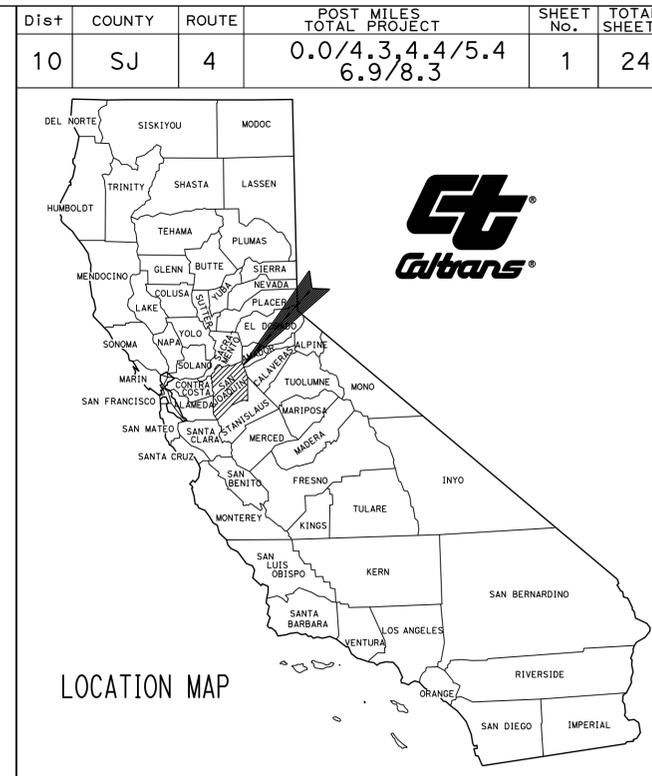

PROJECT MANAGER
 ARVINDER BAJWA
 DESIGN ENGINEER
 NOMER GUTIERREZ

BEGIN CONSTRUCTION
PM 0.0

END CONSTRUCTION
PM 8.3

End Work
PM 8.6


LOCATION 3
PM 6.9 TO PM 8.3

LOCATION 2
PM 4.4 TO PM 5.4

Richard J. Boyer 1/30/15
REGISTERED CIVIL ENGINEER DATE

February 2, 2015
PLANS APPROVAL DATE

THE STATE OF CALIFORNIA OR ITS OFFICERS OR AGENTS SHALL NOT BE RESPONSIBLE FOR THE ACCURACY OR COMPLETENESS OF SCANNED COPIES OF THIS PLAN SHEET.

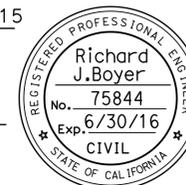

THE CONTRACTOR SHALL POSSESS THE CLASS (OR CLASSES) OF LICENSE AS SPECIFIED IN THE "NOTICE TO BIDDERS."

NO SCALE

CONTRACT No.	10-3A7504
PROJECT ID	1013000253

STATE OF CALIFORNIA - DEPARTMENT OF TRANSPORTATION
Caltrans
 DESIGN
 FUNCTIONAL SUPERVISOR
 NOMER GUTTIEREZ
 CALCULATED/DESIGNED BY
 CHECKED BY
 ROLI ELSOTARI
 RICHARD BOYER
 REVISED BY
 DATE REVISED
 RE
 11-21-14
 RE
 1-14-15
 RE
 1-29-15

NOTES:

1. DIMENSIONS OF THE PAVEMENT STRUCTURES (STRUCTURAL SECTIONS) ARE SUBJECT TO TOLERANCES SPECIFIED IN THE STANDARD SPECIFICATIONS.
2. FOR ACCURATE RIGHT OF WAY DATA, CONTACT RIGHT OF WAY ENGINEERING AT THE DISTRICT OFFICE.
3. EXISTING UTILITY FACILITIES HAVE NOT BEEN PLOTTED ON THESE PLANS
4. LOCATIONS OF LEVELING COURSE TO BE DETERMINED BY ENGINEER.
5. FOR HMA DIKE LOCATIONS, SEE SUMMARY OF QUANTITIES SHEET.
6. FOR REPAIR FAILED AREA DIMENSION AND LOCATIONS, SEE REPAIR FAILED AREA TABLE ON SUMMARY OF QUANTITIES SHEET.

ABBREVIATION:

RHMA-G - RUBBERIZED HOT MIX ASPHALT (GAP GRADED)

DESIGN DESIGNATION

HMA OVERLAY
 ADT 2014(Exist) =7,200
 ADT 2015 =7,300
 ADT 2035 =10,300
 DHV =1,030

PAVEMENT CLIMATE REGION


SAN JOAQUIN VALLEY

Dist	COUNTY	ROUTE	POST MILES TOTAL PROJECT	SHEET No.	TOTAL SHEETS
10	SJ	4	0.0/4.3,4.4/5.4 6.9/8.3	2	24


Richard J. Boyer 1/30/15
 REGISTERED CIVIL ENGINEER DATE
 2-2-15
 PLANS APPROVAL DATE

Richard J. Boyer
 No. 75844
 Exp. 6/30/16
 CIVIL
 STATE OF CALIFORNIA

THE STATE OF CALIFORNIA OR ITS OFFICERS OR AGENTS SHALL NOT BE RESPONSIBLE FOR THE ACCURACY OR COMPLETENESS OF SCANNED COPIES OF THIS PLAN SHEET.

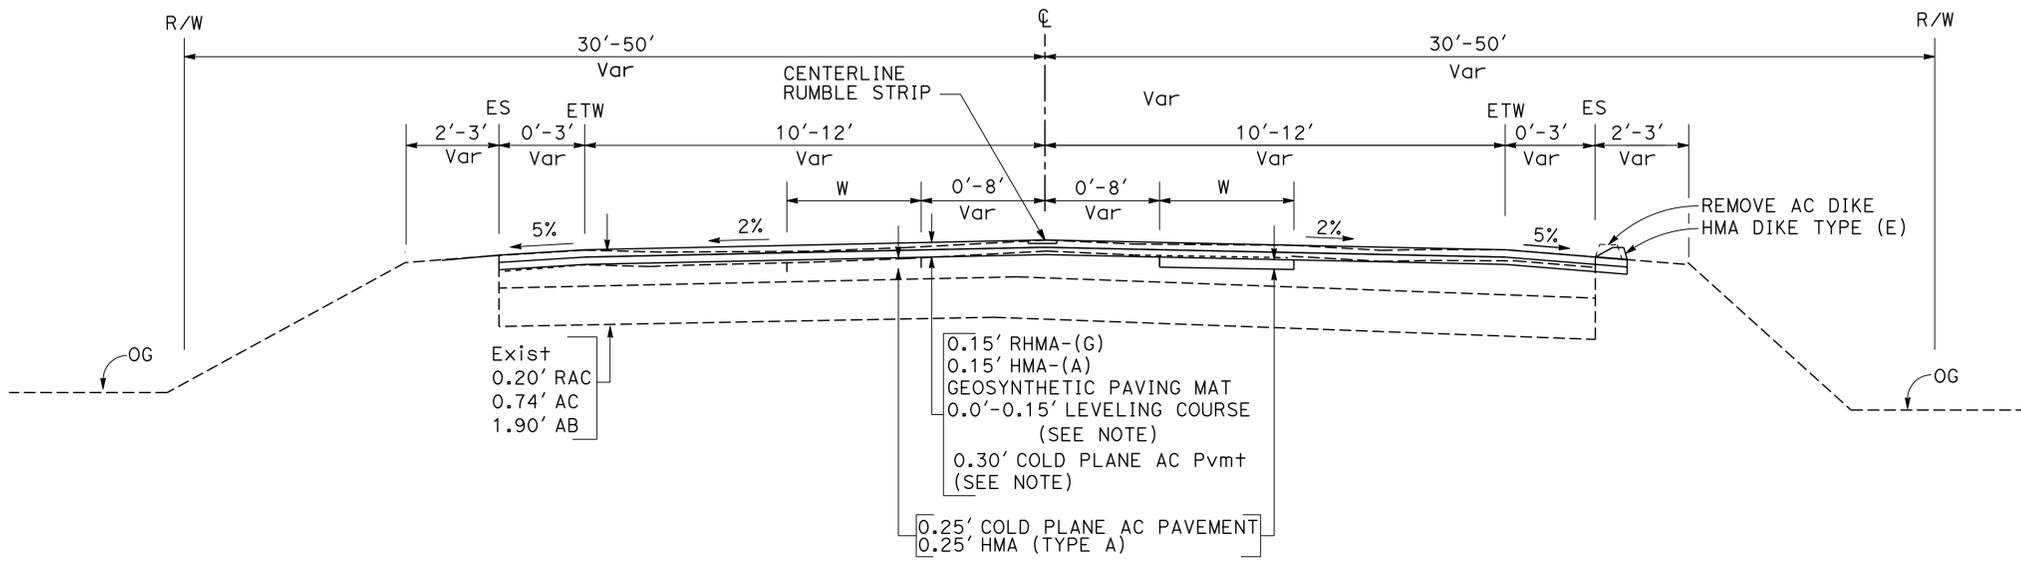

PM 4.50 / 5.40
 LOCATION 2

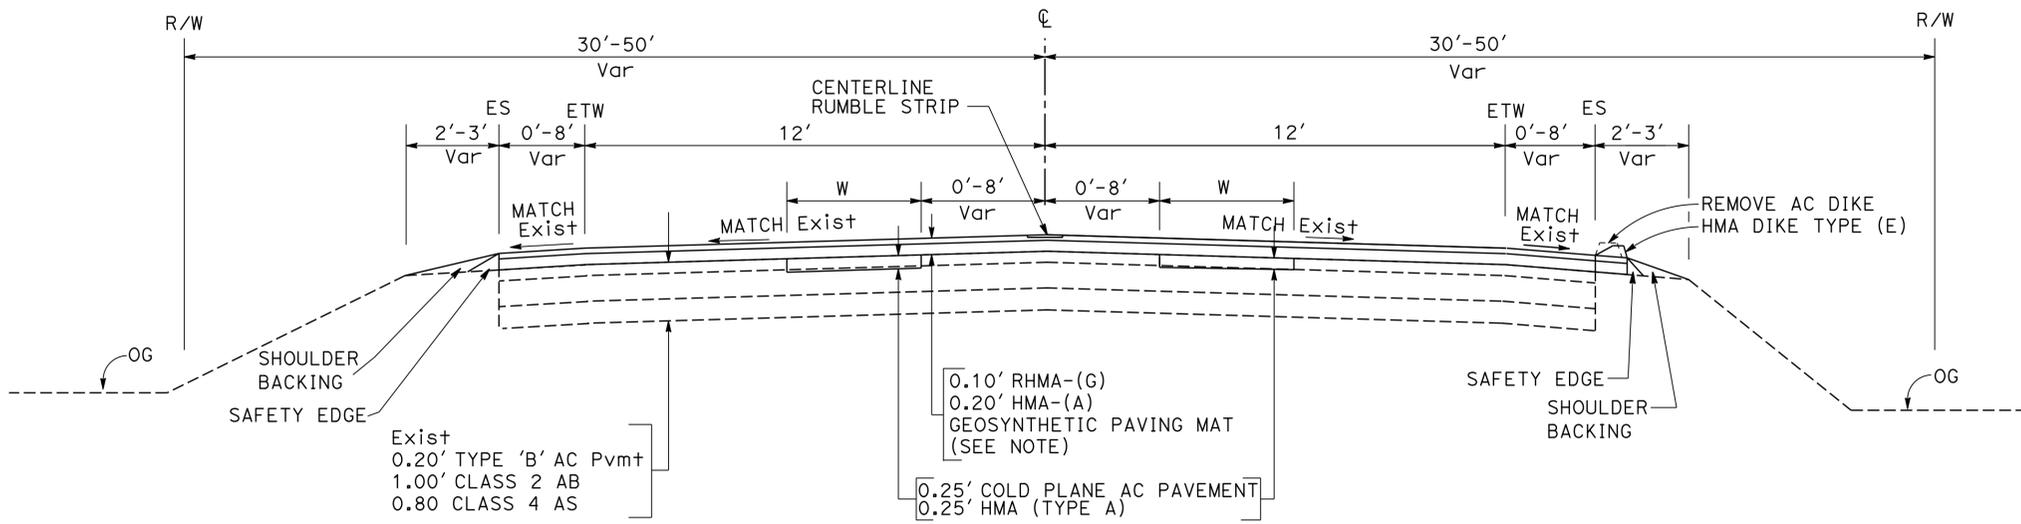

PM 0.0 / 4.30
 LOCATION 1

ROUTE 4

TYPICAL CROSS SECTIONS

NO SCALE

X-1


STATE OF CALIFORNIA - DEPARTMENT OF TRANSPORTATION
Caltrans DESIGN
 FUNCTIONAL SUPERVISOR
 NOMER GUTTIEREZ
 CALCULATED/DESIGNED BY
 CHECKED BY
 ROLI ELSOTARI
 RICHARD BOYER
 REVISED BY
 DATE REVISED
 RE
 1-29-15
 RE
 1-14-15
 RE
 11-21-14

DIST	COUNTY	ROUTE	POST MILES TOTAL PROJECT	SHEET No.	TOTAL SHEETS
10	SJ	4	0.0/4.3,4.4/5.4 6.9/8.3	3	24

Richard J. Boyer 1/30/15
 REGISTERED CIVIL ENGINEER DATE
 2-2-15
 PLANS APPROVAL DATE

Richard J. Boyer
 No. 75844
 Exp. 6/30/16
 CIVIL
 STATE OF CALIFORNIA

THE STATE OF CALIFORNIA OR ITS OFFICERS OR AGENTS SHALL NOT BE RESPONSIBLE FOR THE ACCURACY OR COMPLETENESS OF SCANNED COPIES OF THIS PLAN SHEET.

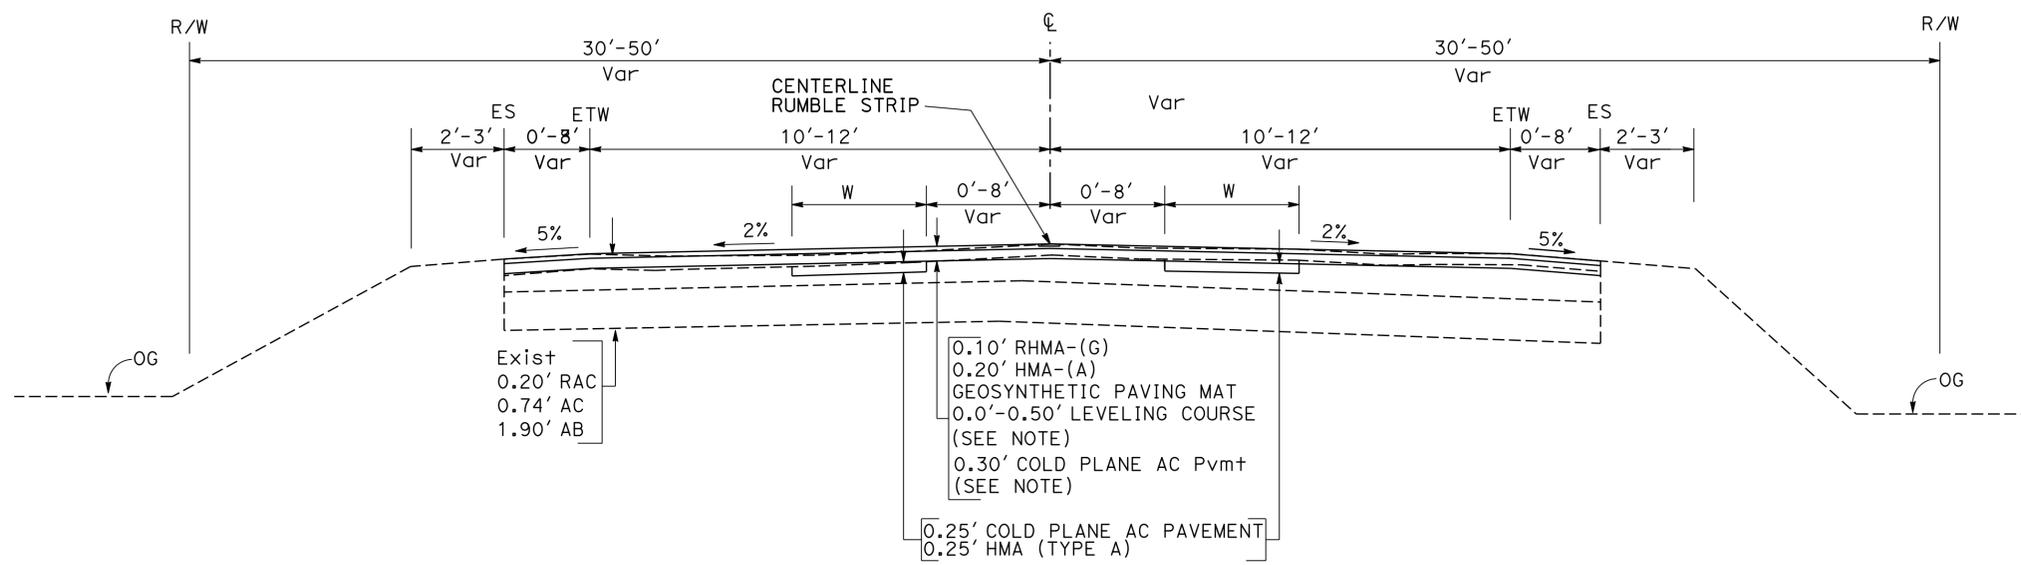

PM 6.9 / 8.3
 LOCATION 3
ROUTE 4

TYPICAL CROSS SECTIONS

NO SCALE **X-2**


Dist	COUNTY	ROUTE	POST MILES TOTAL PROJECT	SHEET No.	TOTAL SHEETS
10	SJ	04	0.0/4.3, 4.4/5.4 6.9/8.3	4	24

Richard J. Boyer 1/30/15
 REGISTERED CIVIL ENGINEER DATE
 2-2-15
 PLANS APPROVAL DATE
 THE STATE OF CALIFORNIA OR ITS OFFICERS OR AGENTS SHALL NOT BE RESPONSIBLE FOR THE ACCURACY OR COMPLETENESS OF SCANNED COPIES OF THIS PLAN SHEET.


REGISTERED PROFESSIONAL ENGINEER
 Richard J. Boyer
 No. 75844
 Exp. 6/30/16
 CIVIL
 STATE OF CALIFORNIA

LEGEND:


- COLD PLANE AC PAVEMENT
RHMA-(G) AND HMA-(A)
- HMA-(A)
- TWO-WAY YELLOW REFLECTIVE MARKER (TYPE D)
- 4" YELLOW STRIPING
- 4" WHITE STRIPING
- RUMBLE STRIPS

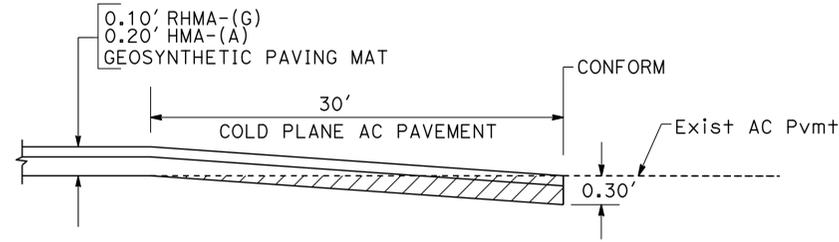


**LONGITUDINAL CONFORM TAPER
AT EXISTING AC PAVEMENT**
PM 0.0, AND 4.3

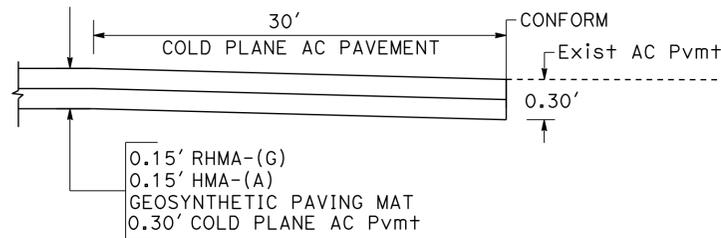




**LONGITUDINAL CONFORM TAPER
AT EXISTING AC PAVEMENT**
PM 4.4, 5.4, 6.9, AND 8.3

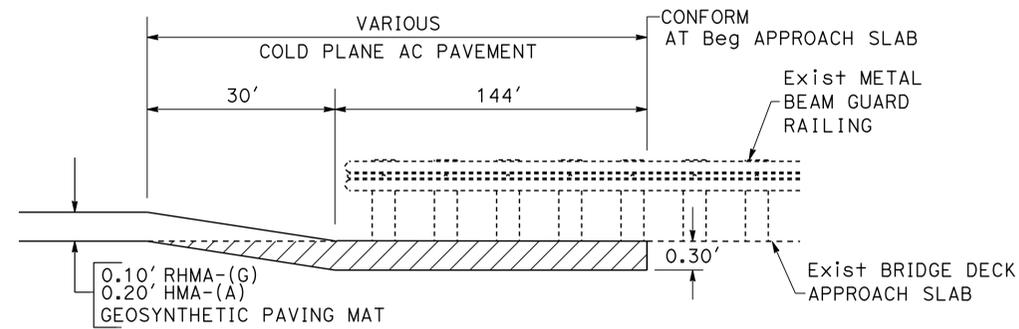




CONFORM TAPER AT MBGR/BRIDGE
PM 4.3 AND 4.4

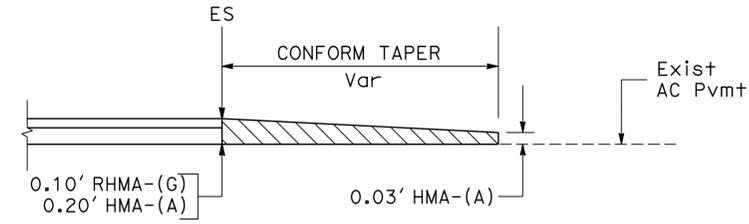

DRIVEWAY CONFORM TAPER

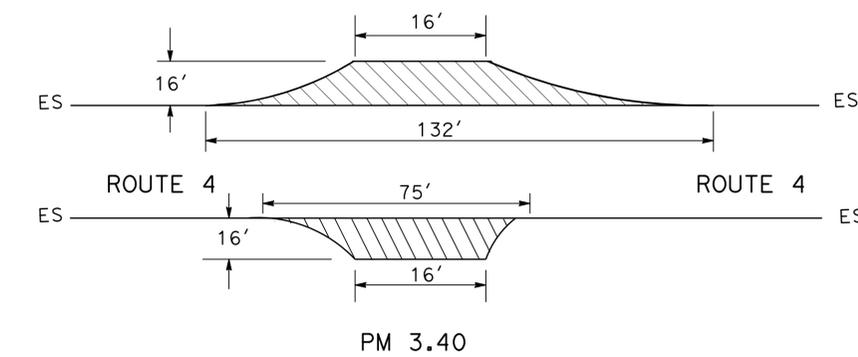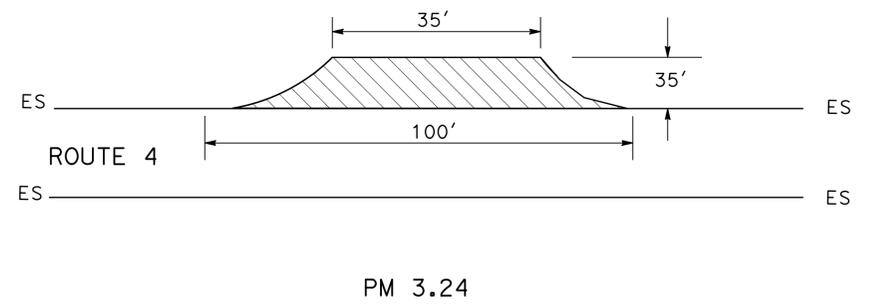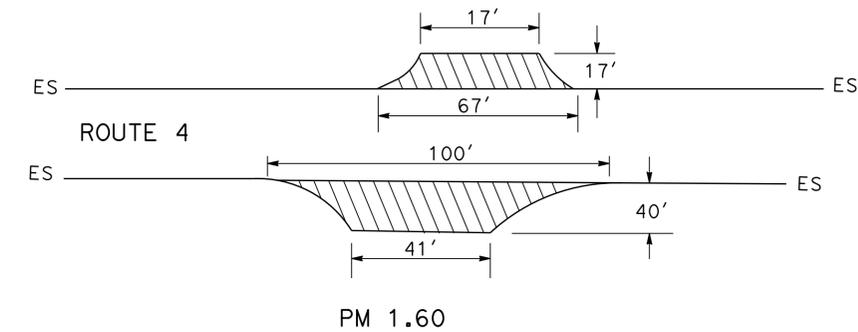

PAVING LIMITS AT DRIVEWAY

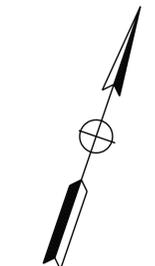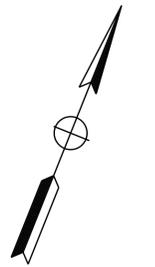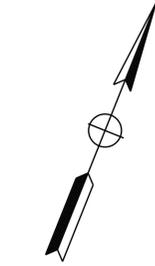


STATE OF CALIFORNIA - DEPARTMENT OF TRANSPORTATION	DESIGN
Caltrans	
FUNCTIONAL SUPERVISOR	NOMER GUTIERREZ
CALCULATED/DESIGNED BY	CHECKED BY
ROLI ELSOTARI	RICHARD BOYER
REVISOR	REVISION
RE	01-29-15
RE	11-20-14
REVISED BY	DATE REVISED
REVISOR	DATE REVISED
RE	01-29-15

Dist	COUNTY	ROUTE	POST MILES TOTAL PROJECT	SHEET No.	TOTAL SHEETS
10	SJ	04	0.0/4.3, 4.4/5.4, 6.9/8.3	5	24

REGISTERED CIVIL ENGINEER DATE 1/30/15
 Richard J. Boyer
 No. 75844
 Exp. 6/30/16
 CIVIL
 STATE OF CALIFORNIA


2-2-15
 PLANS APPROVAL DATE

THE STATE OF CALIFORNIA OR ITS OFFICERS OR AGENTS SHALL NOT BE RESPONSIBLE FOR THE ACCURACY OR COMPLETENESS OF SCANNED COPIES OF THIS PLAN SHEET.

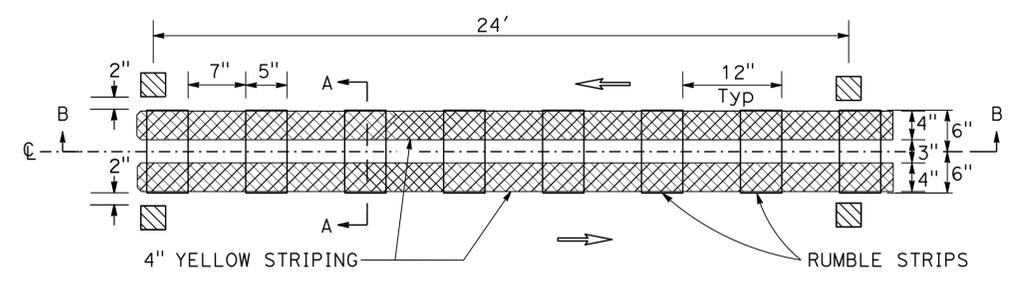


PLAN

**CENTERLINE RUMBLE STRIP (HMA, GROUND-IN INDENTATIONS)
NO PASSING ZONE - DETAIL 22**

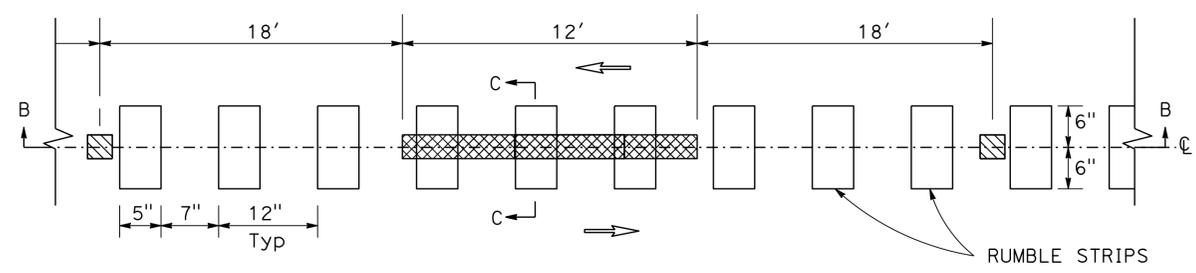


PLAN


**CENTERLINE RUMBLE STRIP (HMA, GROUND-IN INDENTATIONS)
PASSING ZONE - DETAIL 6**

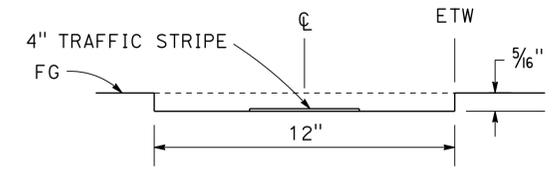

SECTION C-C

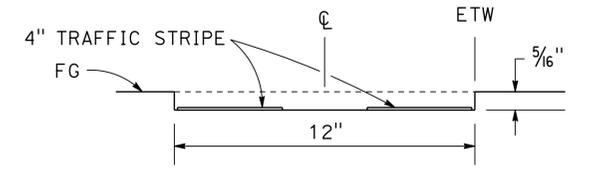

SECTION A-A

 

SECTION B-B

CONSTRUCTION DETAILS
NO SCALE
C-2

STATE OF CALIFORNIA - DEPARTMENT OF TRANSPORTATION	DESIGN
Caltrans	
FUNCTIONAL SUPERVISOR	NOMER GUTIERREZ
CALCULATED/DESIGNED BY	CHECKED BY
ROLI ELSOTARI	RICHARD BOYER
REVISOR	DATE
RE	11-20-14
RE	1-29-15

USERNAME => s121153
DGN FILE => 1013000253ga002

RELATIVE BORDER SCALE IS IN INCHES

UNIT 1454

PROJECT NUMBER & PHASE

10130002531

DATE PLOTTED => 25-FEB-2015
TIME PLOTTED => 08:58


Dist	COUNTY	ROUTE	POST MILES TOTAL PROJECT	SHEET No.	TOTAL SHEETS
10	SJ	4	0.0/4.3/4.4/5.4 6.9/8.3	6	24

REGISTERED CIVIL ENGINEER *nhl* DATE 1/30/15
 HUE NGUYEN No. 74484 Exp. 12/31/15
 PLANS APPROVAL DATE 2-2-15
THE STATE OF CALIFORNIA OR ITS OFFICERS OR AGENTS SHALL NOT BE RESPONSIBLE FOR THE ACCURACY OR COMPLETENESS OF SCANNED COPIES OF THIS PLAN SHEET.

STATIONARY MOUNTED CONSTRUCTION AREA SIGNS

SIGN No. (X)	SIGN CODE		PANEL SIZE	SIGN MESSAGE	NUMBER OF POSTS AND SIZE	NUMBER OF SIGNS
	FEDERAL	CALIFORNIA				
(A)	G20-1		60" x 36"	ROAD WORK NEXT 9 MILES	2 - 4" x 6"	2
(B)	W20-1		36" x 36"	ROAD WORK AHEAD	1 - 4" x 6"	6
(C)	G20-2		36" x 18"	END ROAD WORK	1 - 4" x 4"	4

EXACT LOCATION OF THE CONSTRUCTION AREA SIGNS TO BE DETERMINED BY THE ENGINEER.

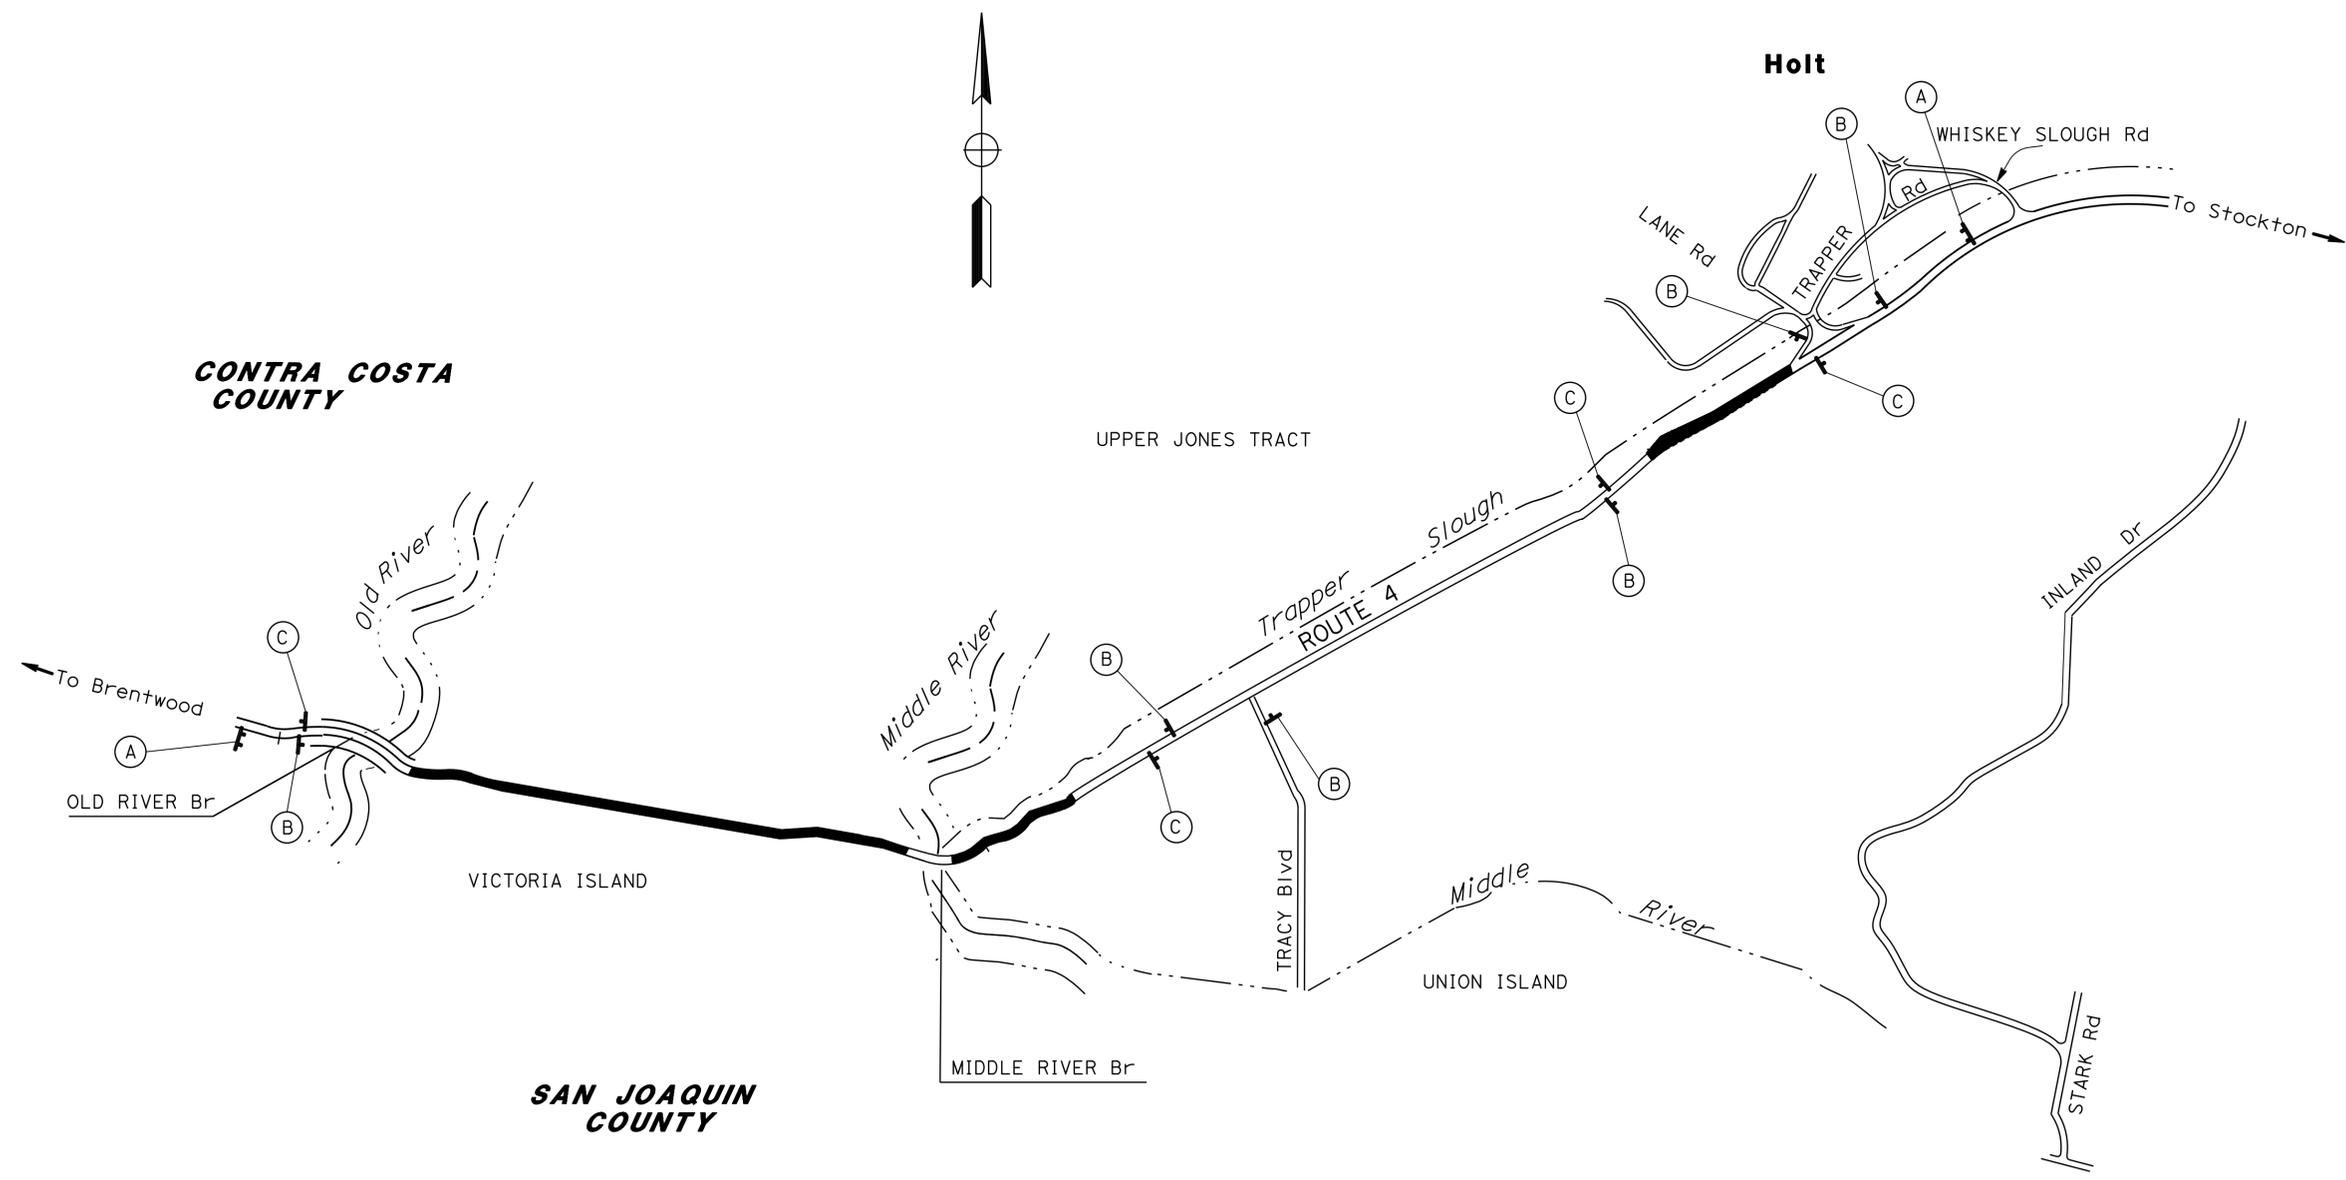

STATE OF CALIFORNIA - DEPARTMENT OF TRANSPORTATION
Caltrans TRAFFIC DESIGN
 FUNCTIONAL SUPERVISOR: MOHAMMED QATAMI
 RAJINI TEKALKOTE: HUE NGUYEN
 REVISOR: RAJINI TEKALKOTE
 DATE REVISION: 11-21-14
 DATE REVISION: 09-18-14
 RT: 1-16-15


CONSTRUCTION AREA SIGNS CS-1

NO SCALE

APPROVED FOR CONSTRUCTION AREA SIGN WORK ONLY


DATE PLOTTED => 25-FEB-2015
 TIME PLOTTED => 08:58

Dist	COUNTY	ROUTE	POST MILES TOTAL PROJECT	SHEET No.	TOTAL SHEETS
10	SJ	4	0.0/4.34/5.4 6.9/8.3	7	24

  1/30/15
 REGISTERED CIVIL ENGINEER DATE

2-2-15
 PLANS APPROVAL DATE

THE STATE OF CALIFORNIA OR ITS OFFICERS
 OR AGENTS SHALL NOT BE RESPONSIBLE FOR
 THE ACCURACY OR COMPLETENESS OF SCANNED
 COPIES OF THIS PLAN SHEET.

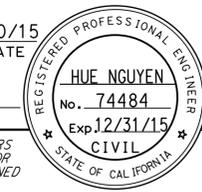

PAVEMENT DELINEATION QUANTITIES

LOCATION		REMOVE YELLOW THERMOPLASTIC TRAFFIC STRIPE (HAZARDOUS WASTE)	THERMOPLASTIC TRAFFIC STRIPE								THERMOPLASTIC PAVEMENT MARKINGS			REMOVE PAVEMENT MARKER	PAVEMENT MARKER (RETRO- REFLECTIVE)		
			4" WHITE SOLID	4" YELLOW SOLID				4" WHITE BROKEN (12-3)	8" WHITE SOLID	TYPE III ARROW	TYPE V ARROW	LIMIT LINE	TYPE		TYPE	TYPE	
				DETAIL	DETAIL	DETAIL	DETAIL										DETAIL
PM/PM	DIR	LF	LF	LF	LF	LF	LF	LF	LF	LF	SQFT	SQFT	SQFT	EA	EA	EA	EA
0.0/5.4	EB	11,572	27,551	1933	17,741	17,709	1933	180					1837		82	1151	
	WB		27,762														
6.9/8.3	EB	27,591	7,392	13,116	1352	449		137	42	33	12					588	
	WB		7,255														
SUBTOTAL			69,960	1933	30,857	1352	18,158	1933			42	33	12		16	82	1739
TOTAL		39,163	104,102				20,091		317	354	87			1837	1837		

STATE OF CALIFORNIA - DEPARTMENT OF TRANSPORTATION
Caltrans
 RAJINI TEKALKOTE
 HUE NGUYEN
 CALCULATED-DESIGNED BY
 CHECKED BY
 FUNCTIONAL SUPERVISOR
 MOHAMMED QATAMI
 TRAFFIC DESIGN

**PAVEMENT DELINEATION
QUANTITIES
PDQ-1**


LAST REVISION
 DATE PLOTTED => 25-FEB-2015
 TIME PLOTTED => 08:58

Dist	COUNTY	ROUTE	POST MILES TOTAL PROJECT	SHEET No.	TOTAL SHEETS
10	SJ	4	0.0/4.3,4.4/5.4 6.9/8.3	8	24

<i>nhl</i>	1/30/15
REGISTERED CIVIL ENGINEER	DATE
2-2-15	
PLANS APPROVAL DATE	


REGISTERED PROFESSIONAL ENGINEER	HUE NGUYEN
No. 74484	
Exp. 12/31/15	
CIVIL	

THE STATE OF CALIFORNIA OR ITS OFFICERS OR AGENTS SHALL NOT BE RESPONSIBLE FOR THE ACCURACY OR COMPLETENESS OF SCANNED COPIES OF THIS PLAN SHEET.

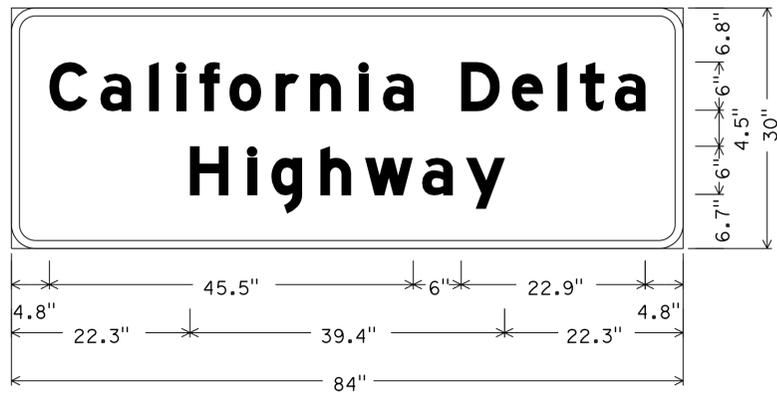


3.0" Radius, 1.0" Border, White on Green;
[California Delta] E Mod; [Highway] E Mod;

SG1(CA)(MOD)
EB PM 0.15

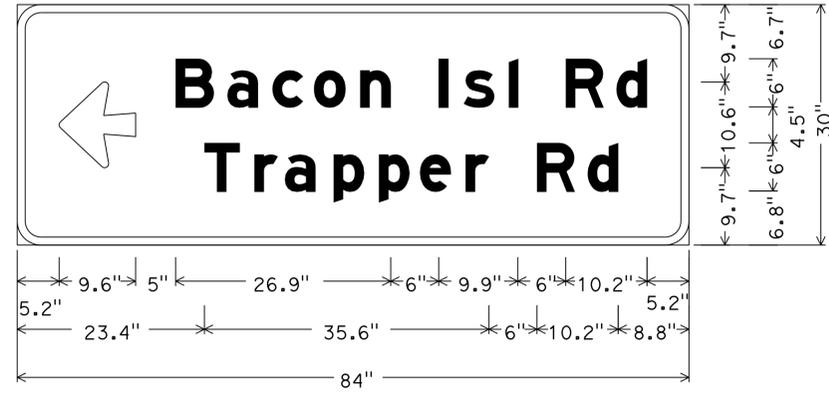

3.0" Radius, 1.0" Border, White on Green;
Arrow 6UC-2LH - 9.6" 180°;
[Bacon Isl Rd] E Mod; [Trapper Rd] E Mod;

G8-22(CA)(MOD)
EB PM 8.09

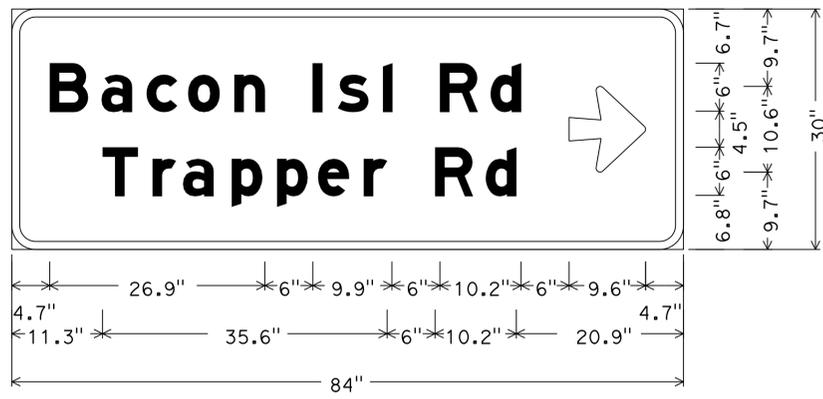

3.0" Radius, 1.0" Border, White on Green;
[Bacon Isl Rd] E Mod; [Trapper Rd] E Mod;
Arrow 6UC-2LH - 9.6" 0°;

G8-22(CA)(MOD)
WB PM 8.27

STATE OF CALIFORNIA - DEPARTMENT OF TRANSPORTATION	FUNCTIONAL SUPERVISOR	CALCULATED-DESIGNED BY	RAJINI TEKALKOTE	REVISED BY	RT	RT	RT
Caltrans	MOHAMMED QATAMI	CHECKED BY	HUE NGUYEN	DATE REVISED	11-24-14	1-16-15	1-28-15
TRAFFIC DESIGN							

Dist	COUNTY	ROUTE	POST MILES TOTAL PROJECT	SHEET No.	TOTAL SHEETS
10	SJ	4	0.0/4.34.4/5.4 6.9/8.3	9	24

REGISTERED CIVIL ENGINEER: *Hue Nguyen* DATE: 1/30/15
 PLANS APPROVAL DATE: 2-2-15

REGISTERED PROFESSIONAL ENGINEER: HUE NGUYEN
 No. 74484
 Exp. 12/31/15
 CIVIL

THE STATE OF CALIFORNIA OR ITS OFFICERS OR AGENTS SHALL NOT BE RESPONSIBLE FOR THE ACCURACY OR COMPLETENESS OF SCANNED COPIES OF THIS PLAN SHEET.

ROADSIDE SIGN QUANTITIES

POST MILE	DIRECTION	SIGN CODE		PANEL SIZE	POST SIZE	SIGN MESSAGE	SINGLE FACED	DOUBLE FACED	BACKGROUND		LEGEND		GRAFFITI FLOW		FURNISH SINGLE SHEET ALUMINUM SIGN FOR RETROREFLECTIVE SHEETING (TYPE XI)		RETROREFLECTIVE SHEETING (TYPE XI)	ROADSIDE SIGN-ONE POST	ROADSIDE SIGN-TWO POST	REMOVE ROADSIDE SIGN	REMOVE ROADSIDE SIGN PANEL	INSTALL ROADSIDE SIGN PANEL ON EXISTING POST	TREATED WOOD WASTE	REMARKS
		FEDERAL	CALIFORNIA						SHEETING COLOR	RETROREFLECTIVITY ASTM TYPE	SHEETING COLOR	RETROREFLECTIVITY ASTM TYPE	STANDARD	PREMIUM	0.063" (UNFRAMED)	0.080" (FRAMED)								
0.12	WB	W4-4aP(MOD)																						
0.12	WB	W4-4aP(MOD)		24" x 18"		PREPARE TO STOP WHEN FLASHING	X		YELLOW	XI	BLACK		X		3.0		3.0					1		MOUNT ON Exist FLASHING BEACON ELECTRICAL POLE
0.15	EB		SG1(CA)(MOD)																				146	
0.15	EB		SG1(CA)(MOD)	84" x 30"	2 - 4" x 6"	CALIFORNIA DELTA HIGHWAY	X		GREEN	XI	WHITE	XI	X		17.5	17.5		1						
3.56	WB	W1-4		36" x 36"		HORIZONTAL ALIGNMENT	X		YELLOW	XI	BLACK		X		9.0		9.0				1	1		
4.27	EB	W1-2(R) W13-1P																					75	
4.27	EB	W1-2(R) W13-1P		36" x 36" 24" x 24"	1 - 4" x 6"	HORIZONTAL ALIGNMENT ADVISORY SPEED PLAQUE (40MPH)	X X		YELLOW YELLOW	XI XI	BLACK BLACK		X X		9.0 4.0	9.0 4.0		1						
4.36	EB	W8-5																					45	
4.36	EB	W8-5		36" x 36"	1 - 4" x 6"	SLIPPERY WHEN WET	X		YELLOW	XI	BLACK		X		9.0		9.0	1			1			45
4.61	EB	W1-2(R)																						
4.61	EB	W1-2(R)		36" x 36"	1 - 4" x 6"	HORIZONTAL ALIGNMENT	X		YELLOW	XI	BLACK		X		9.0		9.0	1						
4.78	WB	W1-1 W13-1P		36" x 36" 24" x 24"		HORIZONTAL ALIGNMENT ADVISORY SPEED PLAQUE (30MPH)	X X		YELLOW YELLOW	XI XI	BLACK BLACK		X X		9.0 4.0	9.0 4.0					1 1	1 1		
4.98	EB	W1-2(R)																					45	
4.98	EB	W1-2(R)		36" x 36"	1 - 4" x 6"	HORIZONTAL ALIGNMENT	X		YELLOW	XI	BLACK		X		9.0		9.0	1						
5.24	WB	W1-2(L) W13-1P																					75	
5.24	WB	W1-2(L) W13-1P		36" x 36" 24" x 24"	1 - 4" x 6"	HORIZONTAL ALIGNMENT ADVISORY SPEED PLAQUE (40MPH)	X X		YELLOW YELLOW	XI XI	BLACK BLACK		X X		9.0 4.0	9.0 4.0		1						
7.30	EB	W1-4 W13-1P																					75	
7.30	EB	W1-4 W13-1P		36" x 36" 24" x 24"	1 - 4" x 6"	HORIZONTAL ALIGNMENT ADVISORY SPEED PLAQUE (45MPH)	X X		YELLOW YELLOW	XI XI	BLACK BLACK		X X		9.0 4.0	9.0 4.0		1						
8.09	EB		G8-22(CA)(MOD)																				146	
8.09	EB		G8-22(CA)(MOD)	84" x 30"	2 - 4" x 6"	<---- BACON Isl Rd/TRAPPER Rd	X		GREEN	XI	WHITE	XI	X		17.5	17.5		1						
8.17	WB	W5-1		36" x 36"		ROAD NARROWS	X		YELLOW	XI	BLACK		X		9.0		9.0				1	1		
8.27	WB		G8-22(CA)(MOD)																				146	
8.27	WB		G8-22(CA)(MOD)	84" x 30"	2 - 4" x 6"	BACON Isl Rd/TRAPPER Rd ---->	X		GREEN	XI	WHITE	XI	X		17.5	17.5		1						
TOTAL															100.0	52.5	152.5	6	3	9	5	5	798	

SIGN QUANTITIES SQ-1

DATE PLOTTED => 25-FEB-2015
 TIME PLOTTED => 08:58

NOTES:

- ACTUAL LOCATIONS AND DIMENSIONS OF REPAIR FAILED AREA VARY IN THE FIELD AND WILL BE DETERMINED BY THE ENGINEER
- * TOTAL INCLUDED IN ROADWAY ITEMS TABLE

REPAIR FAILED AREA

Loc	LOCATION		LENGTH	WIDTH	COLD PLAN AC PAVEMENT	HMA (TYPE A)
	PM	SIDE			SQYD	TON
1	0.45	WB	10'	4'	4.44	0.60
	1.02	WB	20'	4'	8.89	1.20
	1.02	EB	20'	4'	8.89	1.20
	2.30	WB	10'	4'	4.44	0.60
	2.30	WB	90	10'	10.00	13.30
	2.30	EB	250	10'	277.78	37.0
	2.30	EB	60'	10'	66.67	8.90
	3.0	EB	200'	5'	111.11	14.80
	3.0	WB	67'	4'	29.78	4.00
	3.4	WB	14'	10'	15.56	2.10
2	4.0	WB	40	4'	17.78	2.40
	4.5	EB	331'	10'	367.78	49.00
	4.5	EB	175'	4'	77.78	7.80
	4.5	EB	1513'	12'	2017.33	201.70
	4.8	WB	315'	4'	140.00	14.00
3	4.8	WB	216'	6'	144.00	14.40
	4.8	WB	2906'	12'	3874.67	387.50
	5.4	WB	297'	12'	396.00	39.60
	7.0	EB	36'	4'	16.00	2.10
	7.5	EB	66'	4'	29.33	3.90
	7.5	WB	297'	12'	396.00	52.80
	7.5	WB	212'	4'	94.22	12.60
	8.0	WB	1003'	4'	445.78	59.40
	8.0	WB	23'	10'	25.56	3.40
	8.0	EB	397'	10'	441.11	58.80
TOTAL	8.0	EB	645'	4'	286.67	38.20
	8.0	EB	168'	6'	112.00	14.90
	8.25	WB	314'	4'	139.55	18.60
	8.25	EB	671'	10'	745.56	99.40
	8.25	EB	202'	4'	89.78	12.00
	8.25	EB	58'	8'	51.56	6.90
TOTAL					10,536*	1183*

ROADWAY ITEMS

LOCATION	HOT MIX ASPHALT (TYPE A)	RUBBERIZED HOT MIX ASPHALT (GAP GRADED)	TACK COAT	SHOULDER BACKING	HOT MIX ASPHALT (LEVELING COURSE)	GEOSYNTHETIC PAVEMENT INTERLAYER (PAVING MAT)	COLD PLANE AC PAVEMENT
	TON						SQYD
PM 6.90/8.30 PM 4.50/5.40 PM 0.00/4.25	17,007.5	9,217	53	2854	12,200	131,120	
REPAIR FAILED AREA	1183		5				10,536
PM 6.90/8.30 PM 4.50/5.40							46,350
CONFORM TAPER AT PRIVATE DRIVEWAYS	135	60.7	3				
CONFORM TAPERS AT MBGR	68	34	2				
CONFORM TAPER AT EXISTING PAVEMENT	180	115	1				
AC DIKE (TYPE E)	16		1				
SAFETY EDGE		150					
TOTAL	18,590.5	9,576.7	65	2854	12,200	131,120	56,886

CENTERLINE RUMBLE STRIP (HMA, GROUND-IN INDENTATIONS)

Loc	LOCATION	Sta	DESCRIPTION
	PM/PM		
1	0.0/4.30	272.9	CENTERLINE RUMBLE STRIP
2	4.40/5.40	47.5	CENTERLINE RUMBLE STRIP
3	6.90/8.30	73.9	CENTERLINE RUMBLE STRIP
TOTAL		394.3	

DIKE QUANTITIES

LOCATION			AC DIKE (TYPE E)	HMA (TYPE E)	REMOVE AC DIKE
Loc	PM/PM	SIDE	LF	TON	LF
1	3.21/3.27	R+	316	8.1	316
	4.54/4.59	R+	284	7.4	284
TOTAL			600	16*	600

Dist	COUNTY	ROUTE	POST MILES TOTAL PROJECT	SHEET No.	TOTAL SHEETS
10	SJ	4	0.0/4.3, 4.4/5.4 6.9/8.3	10	24

Richard J. Boyer 1/30/15
 REGISTERED CIVIL ENGINEER DATE

Richard J. Boyer
 No. 75844
 Exp. 6/30/16
 CIVIL

2-2-15
 PLANS APPROVAL DATE

THE STATE OF CALIFORNIA OR ITS OFFICERS OR AGENTS SHALL NOT BE RESPONSIBLE FOR THE ACCURACY OR COMPLETENESS OF SCANNED COPIES OF THIS PLAN SHEET.

SUMMARY OF QUANTITIES

Q-1

Dist	COUNTY	ROUTE	POST MILES TOTAL PROJECT	SHEET No.	TOTAL SHEETS
10	SJ	4	0.0/4.3,4.4/5.4 6.9/8.3	11	24

<i>Jaspal Singh</i>	1/30/15
REGISTERED ELECTRICAL ENGINEER	DATE
2-2-15	
PLANS APPROVAL DATE	

REGISTERED PROFESSIONAL ENGINEER
JASPAL SINGH
 No. 16657
 Exp. 6/30/16
 ELECTRICAL
 STATE OF CALIFORNIA

THE STATE OF CALIFORNIA OR ITS OFFICERS OR AGENTS SHALL NOT BE RESPONSIBLE FOR THE ACCURACY OR COMPLETENESS OF SCANNED COPIES OF THIS PLAN SHEET.

LEGEND:

 

- 1 Exist MODEL 2070E CONTROLLER ASSEMBLY FOR FUTURE USE.
- 2 Exist MODEL 334L CONTROLLER CABINET FOR TMS.
- 3 AB Exist LOOP DETECTORS AND INSTALL LOOP DETECTORS AS SHOWN IN DETAIL A ON THIS SHEET.

NOTE:


FOR ACCURATE RIGHT OF WAY DATA, CONTACT RIGHT OF WAY ENGINEERING AT THE DISTRICT OFFICE.

ABBREVIATION:

PG&E - PACIFIC GAS AND ELECTRIC

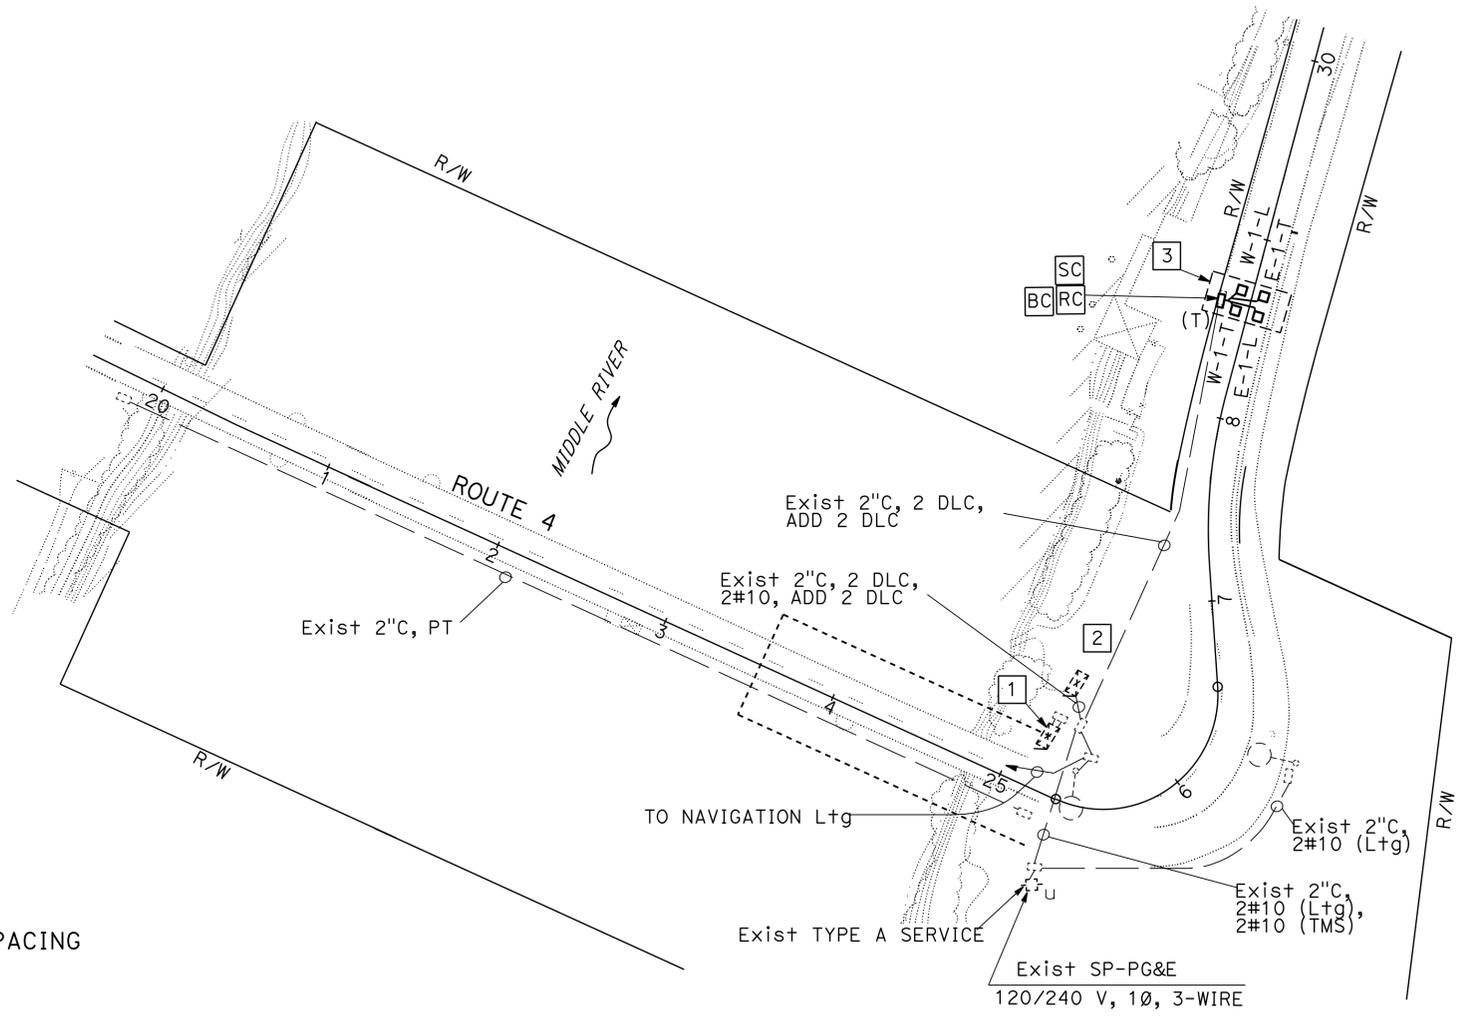

TYPICAL LOOP DETECTOR SPACING

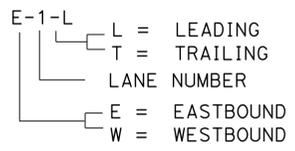

LOOP DETECTOR IDENTIFICATION
DETAIL A

**MODIFY TRAFFIC MONITORING STATION
E-1**

APPROVED FOR ELECTRICAL WORK ONLY

SCALE: 1"=50'

STATE OF CALIFORNIA - DEPARTMENT OF TRANSPORTATION
Caltrans ELECTRICAL DESIGN
FUNCTIONAL SUPERVISOR
ALI BAKHDOUD
CALCULATED-DESIGNED BY
CHECKED BY
JASPAL SINGH
JASPAL SINGH
REVISOR
DATE
1-21-15
JS

STATE OF CALIFORNIA - DEPARTMENT OF TRANSPORTATION
Caltrans® ELECTRICAL DESIGN

BORDER LAST REVISED 7/2/2010

USERNAME => s120300
 DGN FILE => 1013000253ud002.dgn

RELATIVE BORDER SCALE IS IN INCHES



UNIT 1515

PROJECT NUMBER & PHASE 10130002531


NOTE:


THE QUANTITIES SHOWN IN THIS TABLE ARE NOT SEPARATE PAY ITEMS, FOR INFORMATION ONLY.
 FOR COMPLETE ELECTRICAL WORK, SEE ELECTRICAL PLANS.

MODIFY TRAFFIC MONITORING STATION

SHEET No.	TYPE A LOOP DETECTOR	No. 5 (T) PB	DLC	1/2" C, TYPE 3
	EA		LF	
E-1	4	1	520	10

Dist	COUNTY	ROUTE	POST MILES TOTAL PROJECT	SHEET No.	TOTAL SHEETS
10	SJ	4	0.0/4.3,4.4/5.4 6.9/8.3	12	24

  1/30/15
 REGISTERED ELECTRICAL ENGINEER DATE
 2-2-15
 PLANS APPROVAL DATE

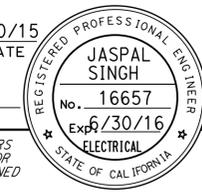

THE STATE OF CALIFORNIA OR ITS OFFICERS OR AGENTS SHALL NOT BE RESPONSIBLE FOR THE ACCURACY OR COMPLETENESS OF SCANNED COPIES OF THIS PLAN SHEET.

ELECTRICAL QUANTITIES
E-2

LAST REVISION DATE PLOTTED => 25-FEB-2015
 1-21-15 TIME PLOTTED => 08:58

	M	
Maint	MAINTENANCE	
Max	MAXIMUM	
MB	METAL BEAM	
MBB	METAL BEAM BARRIER	
MBGR	METAL BEAM GUARD RAILING	
Med	MEDIAN	
MGS	MIDWEST GUARDRAIL SYSTEM	
MH	MANHOLE	
Min	MINIMUM	
Misc	MISCELLANEOUS	
Misc I & S	MISCELLANEOUS IRON AND STEEL	
Mkr	MARKER	
Mod	MODIFIED, MODIFY	
Mon	MONUMENT	
MP	METAL PLATE	
MPGR	METAL PLATE GUARD RAILING	
MR	MOVEMENT RATING	
MSE	MECHANICALLY STABILIZED EMBANKMENT	
Mt	MOUNTAIN, MOUNT	
MtI	MATERIAL	
MVP	MAINTENANCE VEHICLE PULLOUT	
	N	
N	NORTH	
NB	NORTHBOUND	
No.	NUMBER (MUST HAVE PERIOD)	
Nos.	NUMBERS (MUST HAVE PERIOD)	
NPS	NOMINAL PIPE SIZE	
NS	NEAR SIDE	
NSP	NEW STANDARD PLAN	
NTS	NOT TO SCALE	
	O	
Obir	OBLITERATE	
OC	OVERCROSSING	
OD	OUTSIDE DIAMETER	
OF	OUTSIDE FACE	
OG	ORIGINAL GROUND	
OGAC	OPEN GRADED ASPHALT CONCRETE	
OGFC	OPEN GRADED FRICTION COURSE	
OH	OVERHEAD	
OHWM	ORDINARY HIGH WATER MARK	
O-O	OUT TO OUT	
Opp	OPPOSITE	
OSD	OVERSIDE DRAIN	
	P	
p	PAGE	
PAP	PERFORATED ALUMINUM PIPE	
PB	PULL BOX	
PC	POINT OF CURVATURE, PRECAST	
PCC	POINT OF COMPOUND CURVE, PORTLAND CEMENT CONCRETE	
PCMS	PORTABLE CHANGEABLE MESSAGE SIGN	
PCP	PERFORATED CONCRETE PIPE, PRESTRESSED CONCRETE PIPE	
PCVC	POINT OF COMPOUND VERTICAL CURVE	
PEC	PERMIT TO ENTER AND CONSTRUCT	
Ped	PEDESTRIAN	
Ped OC	PEDESTRIAN OVERCROSSING	
Ped UC	PEDESTRIAN UNDERCROSSING	
Perm MtI	PERMEABLE MATERIAL	

	P continued	
PG	PROFILE GRADE	
PI	POINT OF INTERSECTION	
PJP	PARTIAL JOINT PENETRATION	
Pkwy	PARKWAY	
PL, PL	PLATE	
P/L	PROPERTY LINE	
PM	POST MILE, TIME FROM NOON TO MIDNIGHT	
PN	PAVING NOTCH	
POC	POINT OF HORIZONTAL CURVE	
POT	POINT OF TANGENT	
POVC	POINT OF VERTICAL CURVE	
PP	PIPE PILE, PLASTIC PIPE, POWER POLE	
PPL	PERFORMED PERMEABLE LINER	
PPP	PERFORATED PLASTIC PIPE	
PRC	POINT OF REVERSE CURVE	
PRF	PAVEMENT REINFORCING FABRIC	
PRVC	POINT OF REVERSE VERTICAL CURVE	
PS&E	PLANS, SPECIFICATIONS AND ESTIMATES	
PS, P/S	PRESTRESSED	
PSP	PERFORATED STEEL PIPE	
PT	POINT OF TANGENCY	
PVC	POLYVINYL CHLORIDE	
Pvmt	PAVEMENT	
	Q	
Qty	QUANTITY	
	R	
R	RADIUS	
R & D	REMOVE AND DISPOSE	
R & S	REMOVE AND SALVAGE	
R/C	RATE OF CHANGE	
RCA	REINFORCED CONCRETE ARCH	
RCB	REINFORCED CONCRETE BOX	
RCP	REINFORCED CONCRETE PIPE	
RCPA	REINFORCED CONCRETE PIPE ARCH	
Rd	ROAD	
Reinf	REINFORCED, REINFORCEMENT, REINFORCING	
Rel	RELOCATE	
Repl	REPLACEMENT	
Ret	RETAINING	
Rev	REVISED, REVISION	
Rdwy	ROADWAY	
RHMA	RUBBERIZED HOT MIX ASPHALT	
Riv	RIVER	
RM	ROAD-MIXED	
RP	RADIUS POINT, REFERENCE POINT	
RR	RAILROAD	
RSP	ROCK SLOPE PROTECTION, REVISED STANDARD PLAN	
Rt	RIGHT	
Rte	ROUTE	
RW	REDWOOD, RETAINING WALL	
R/W	RIGHT OF WAY	
Rwy	RAILWAY	

	S	
S	SOUTH, SUPPLEMENT	
SAE	STRUCTURE APPROACH EMBANKMENT	
Salv	SALVAGE	
SAPP	STRUCTURAL ALUMINUM PLATE PIPE	
SB	SOUTHBOUND	
SC	SAND CUSHION	
SCSP	SLOTTED CORRUGATED STEEL PIPE	
SD	STORM DRAIN	
Sec	SECOND, SECTION	
Sep	SEPARATION	
SG	SUBGRADE	
Shld	SHOULDER	
Sht	SHEET	
Sim	SIMILAR	
SL	STATION LINE	
SM	SELECTED MATERIAL	
Spec	SPECIAL, SPECIFICATIONS	
SPP	SLOTTED PLASTIC PIPE	
SS	SLOPE STAKE	
SSBM	STRAP AND SADDLE BRACKET METHOD	
SSD	STRUCTURAL SECTION DRAIN	
SSPA	STRUCTURAL STEEL PLATE ARCH	
SSPP	STRUCTURAL STEEL PLATE PIPE	
SSPPA	STRUCTURAL STEEL PLATE PIPE ARCH	
SSRP	STEEL SPIRAL RIB PIPE	
St	STREET	
Sta	STATION	
STBB	SINGLE THRIE BEAM BARRIER	
Std	STANDARD	
Str	STRUCTURE	
Surf	SURFACING	
SW	SIDEWALK, SOUND WALL	
Swr	SEWER	
Sym	SYMMETRICAL	
S4S	SURFACE 4 SIDES	
	T	
T	SEMI-TANGENT	
Tan	TANGENT	
TBB	THRIE BEAM BARRIER	
Tbr	TIMBER	
TC	TOP OF CURB	
TCB	TRAFFIC CONTROL BOX	
TCE	TEMPORARY CONSTRUCTION EASEMENT	
TeI	TELEPHONE	
Temp	TEMPORARY	
TG	TOP OF GRADE	
Tot	TOTAL	
TP	TELEPHONE POLE	
TPB	TREATED PERMEABLE BASE	
TPM	TREATED PERMEABLE MATERIAL	
Trans	TRANSITION	

	T continued	
TS	TRANSVERSE, TRAFFIC SIGNAL, TUBULAR STEEL	
Typ	TYPICAL	U
UC	UNDERCROSSING	
UD	UNDERDRAIN	
UG	UNDERGROUND	
UON	UNLESS OTHERWISE NOTED	
UP	UNDERPASS	V
V	VALVE, DESIGN SPEED	
Var	VARIABLE, VARIES	
VC	VERTICAL CURVE	
VCP	VITRIFIED CLAY PIPE	
Vert	VERTICAL	
Via	VIADUCT	
Vol	VOLUME	W
W	WEST, WIDTH	
WB	WESTBOUND	
WH	WEEP HOLE	
WM	WIRE MESH	
WS	WATER SURFACE	
WSP	WELDED STEEL PIPE	
Wt	WEIGHT	
WV	WATER VALVE	
WW	WINGWALL	
WWLOL	WINGWALL LAYOUT LINE	X
X Sec	CROSS SECTION	
Xing	CROSSING	Y
Yr	YEAR	
Yrs	YEARS	

Dist	COUNTY	ROUTE	POST MILES TOTAL PROJECT	SHEET No.	TOTAL SHEETS
10	SJ	4	0.0/4.34.4/5.4 6.9/8.3	13	24

Grace M. Tsushima
REGISTERED CIVIL ENGINEER

July 19, 2013
PLANS APPROVAL DATE

REGISTERED PROFESSIONAL ENGINEER
 Grace M. Tsushima
 No. C49814
 Exp. 9-30-14
 CIVIL
 STATE OF CALIFORNIA

THE STATE OF CALIFORNIA OR ITS OFFICERS OR AGENTS SHALL NOT BE RESPONSIBLE FOR THE ACCURACY OR COMPLETENESS OF SCANNED COPIES OF THIS PLAN SHEET.

TO ACCOMPANY PLANS DATED 2-2-15

UNIT OF MEASUREMENT SYMBOLS:

Some of the symbols used in the project plan quantity tables and in the Bid Item List are:

TABLE A

SYMBOL USED	DEFINITIONS
ACRE	ACRE
CF	CUBIC FOOT
CY	CUBIC YARD
EA	EACH
GAL	GALLON
LB	POUND
LF	LINEAR FOOT
SQFT	SQUARE FOOT
SQYD	SQUARE YARD
STA	100 FEET
TAB	TABLET
TON	2,000 POUNDS

Some of the symbols used in the plans other than in the project plan quantity tables are:

TABLE B

SYMBOL USED	DEFINITIONS
ksi	KIPS PER SQUARE INCH
ksf	KIPS PER SQUARE FOOT
psi	POUNDS PER SQUARE INCH
psf	POUNDS PER SQUARE FOOT
lb/ft ³ , pcf	POUNDS PER CUBIC FOOT
tsf	TONS PER SQUARE FOOT
mph, MPH *	MILES PER HOUR
ø	NOMINAL DIAMETER
oz	OUNCE
lb	POUND
kíp	1,000 POUNDS
cal	CALORIE
ft	FOOT OR FEET
gal	GALLON

* For use on a sign panel only

STATE OF CALIFORNIA
DEPARTMENT OF TRANSPORTATION


**ABBREVIATIONS
(SHEET 2 OF 2)**

NO SCALE


RSP A10B DATED JULY 19, 2013 SUPERSEDES STANDARD PLAN A10B
DATED MAY 20, 2011 - PAGE 2 OF THE STANDARD PLANS BOOK DATED 2010.

2010 REVISED STANDARD PLAN RSP A10B


TO ACCOMPANY PLANS DATED 2-2-15

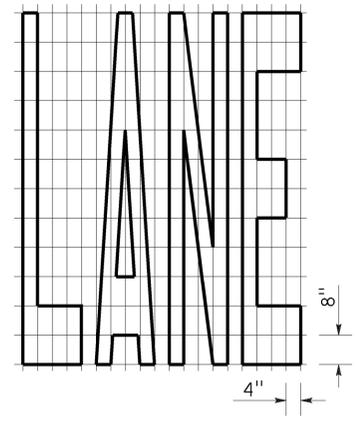


A=24 ft²

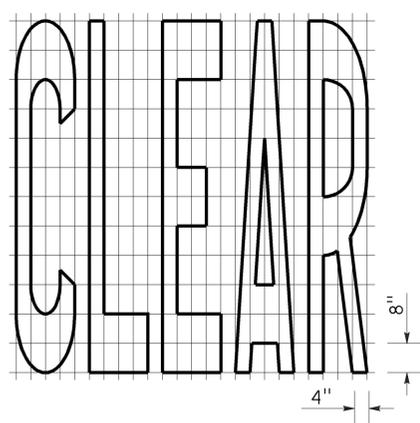


A=27 ft²

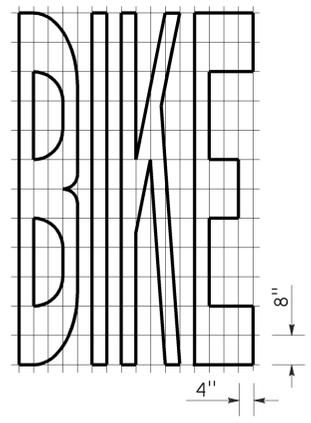


A=21 ft²

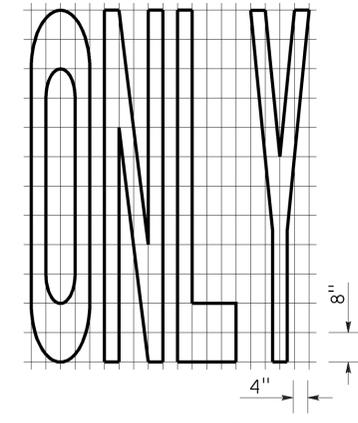


A=22 ft²

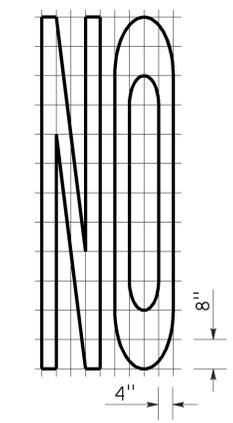


A=14 ft²

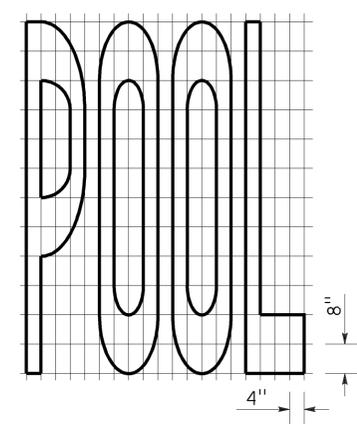


A=23 ft²

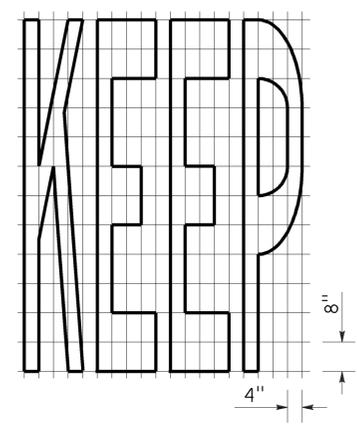


A=24 ft²

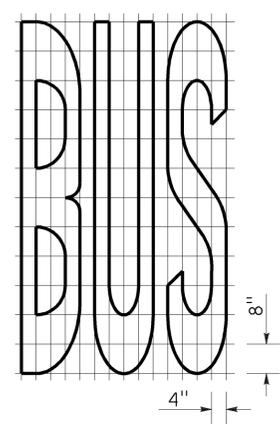

A=20 ft²


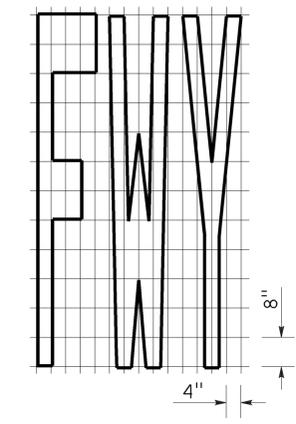


A=16 ft²

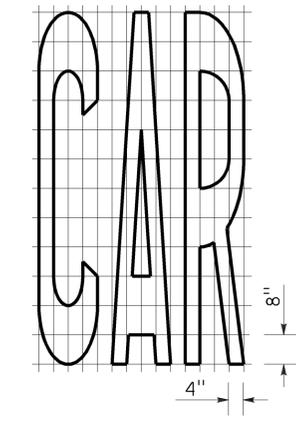


A=17 ft²


WORD MARKINGS			
ITEM	ft ²	ITEM	ft ²
LANE	24	NO	14
POOL	23	BIKE	21
CAR	17	BUS	20
CLEAR	27	ONLY	22
KEEP	24	FWY	16

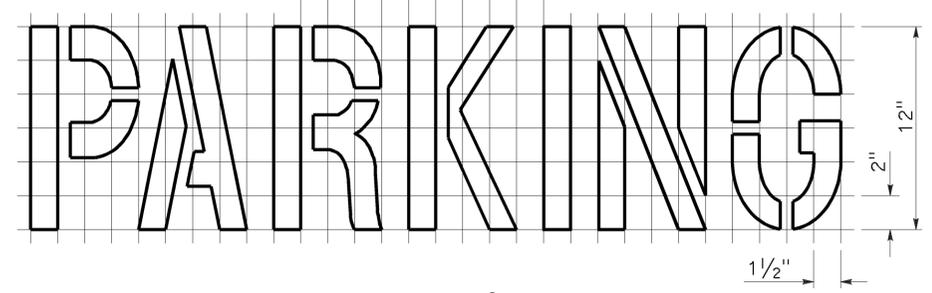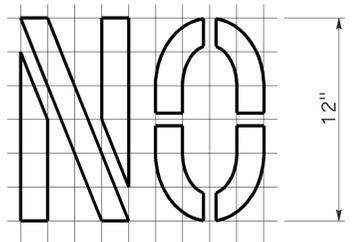

A=2 ft²
See Notes 6 and 7

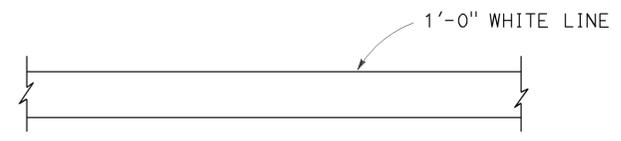

LIMIT LINE (STOP LINE)

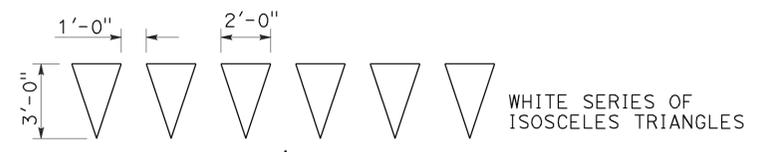

YIELD LINE

NOTES:


1. If a message consists of more than one word, it should read "UP", i.e., the first word should be nearest the driver.
2. The space between words should be at least four times the height of the characters for low speed roads, but not more than ten times the height of the characters. The space may be reduced appropriately where there is limited space because of local conditions.
3. Minor variations in dimensions may be accepted by the Engineer.
4. Portions of a letter, number or symbol may be separated by connecting segments not to exceed 2" in width.
5. The words "NO PARKING" pavement marking is to be used for parking facilities. For typical locations of markings, see Standard Plans A90A and A90B.
6. The words "NO PARKING", shall be painted in white letters no less than 1'-0" high on a contrasting background and located so that it is visible to traffic enforcement officials.

STATE OF CALIFORNIA
DEPARTMENT OF TRANSPORTATION
**PAVEMENT MARKINGS
WORDS, LIMIT AND YIELD LINES**
NO SCALE


RSP A24E DATED JULY 20, 2012 SUPERSEDES STANDARD PLAN A24E
DATED MAY 20, 2011 - PAGE 17 OF THE STANDARD PLANS BOOK DATED 2010.

2010 REVISED STANDARD PLAN RSP A24E


TO ACCOMPANY PLANS DATED 2-2-15

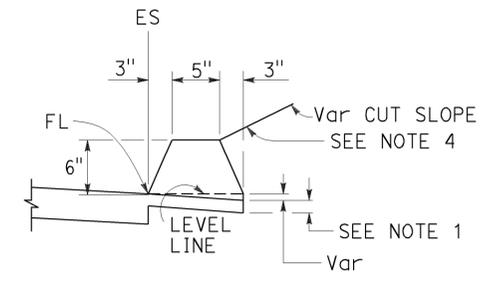


TYPE A
See Note 3

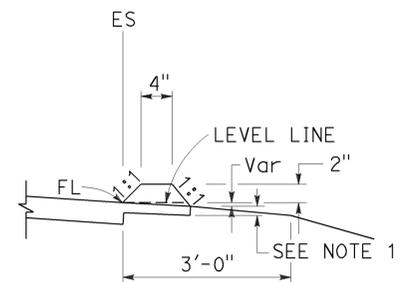


TYPE C

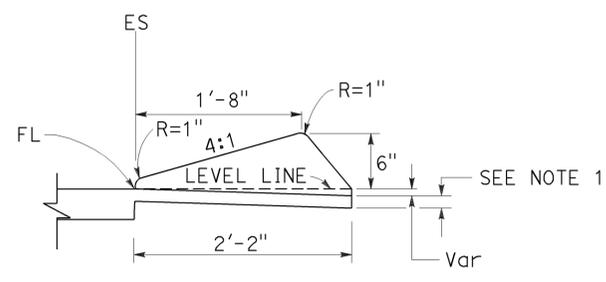

TYPE D

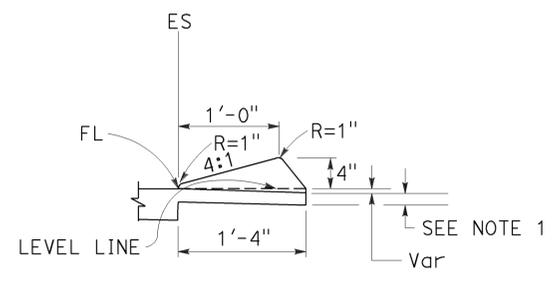


TYPE E

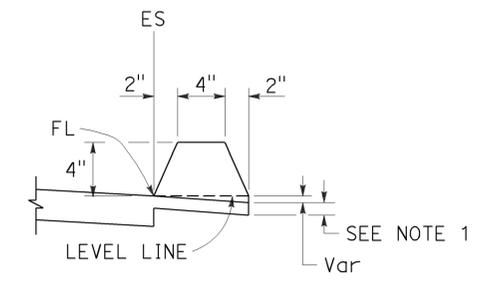


TYPE F
See Note 5


DIKES

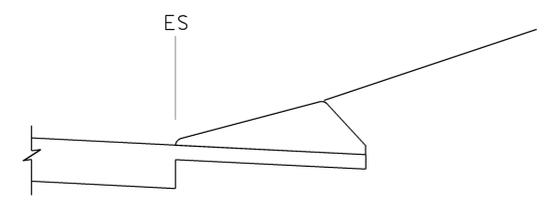


CASE C-1
Cut Slope

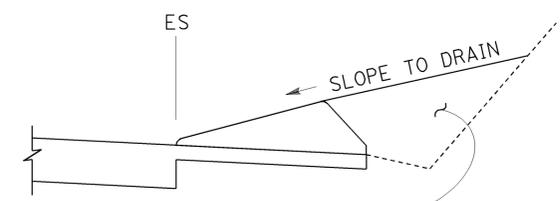

CASE C-2
Cut Slope

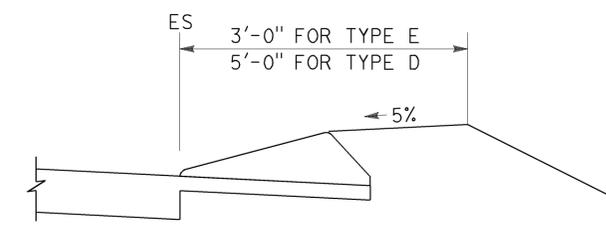

CASE F

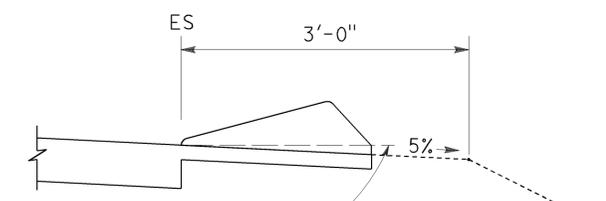

CASE R
See Note 2

TYPE D AND E BACKFILL DETAILS

NOTES:

1. For HMA shoulders only, extend top layer of HMA placed on the shoulder under dike with no joint at the ES. For projects with OGFC shoulders, do not extend OGFC under dike. See project plans for modified dike detail.
2. Case R applies to retrofit only projects where restrictive conditions do not provide enough width for Case F backfill.
3. Type A dike only to be used where restrictive slope conditions do not provide enough width to use Type D or Type E dike.
4. Fill and compact with excavated material to top of dike.
5. Use Type F dike, where dike is required with guard railing installations. See Revised Standard Plan RSP A77N4 for dike positioning details.

DIKE QUANTITIES

TYPE	CUBIC YARDS PER LINEAR FOOT
A	0.0135
C	0.0038
D	0.0293
E	0.0130
F	0.0066

Quantities based on 5% cross slope.

STATE OF CALIFORNIA
DEPARTMENT OF TRANSPORTATION

HOT MIX ASPHALT DIKES

NO SCALE

RSP A87B DATED JULY 19, 2013 SUPERSEDES STANDARD PLAN A87B
DATED MAY 20, 2011 - PAGE 120 OF THE STANDARD PLANS BOOK DATED 2010.


REVISED STANDARD PLAN RSP A87B

2010 REVISED STANDARD PLAN RSP A87B


DIST	COUNTY	ROUTE	POST MILES TOTAL PROJECT	SHEET No.	TOTAL SHEETS
10	SJ	4	0.0/4.34.4/5.4 6.9/8.3	16	24

REGISTERED CIVIL ENGINEER
 November 15, 2013
 PLANS APPROVAL DATE
 THE STATE OF CALIFORNIA OR ITS OFFICERS OR AGENTS SHALL NOT BE RESPONSIBLE FOR THE ACCURACY OR COMPLETENESS OF SCANNED COPIES OF THIS PLAN SHEET.


REGISTERED PROFESSIONAL ENGINEER
 Cornelis M. Hakim
 No. C55610
 Exp. 12-31-14
 CIVIL
 STATE OF CALIFORNIA

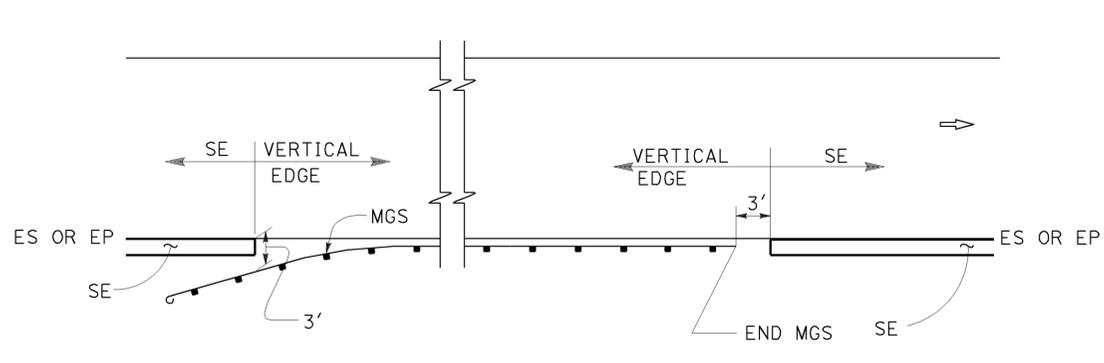


MGS

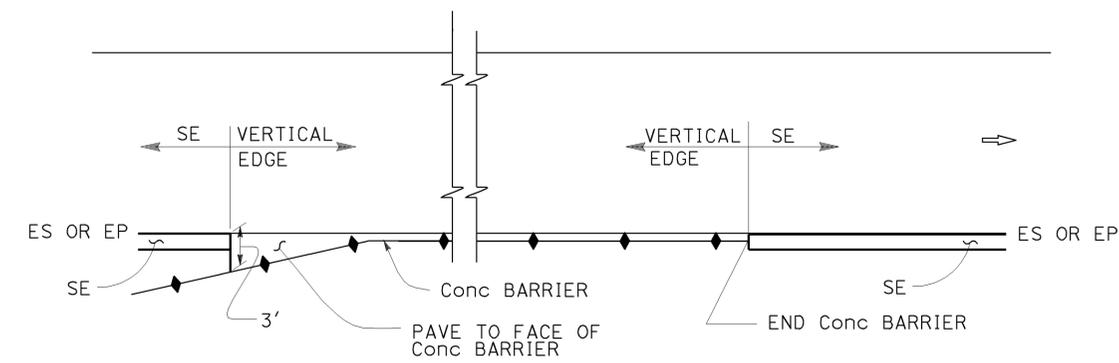


CONCRETE BARRIER

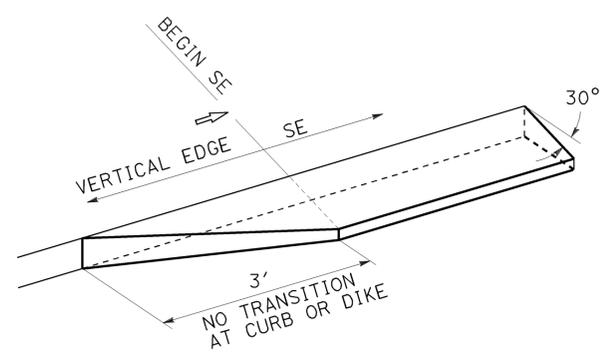

TRANSITION DETAIL FOR CONCRETE ONLY

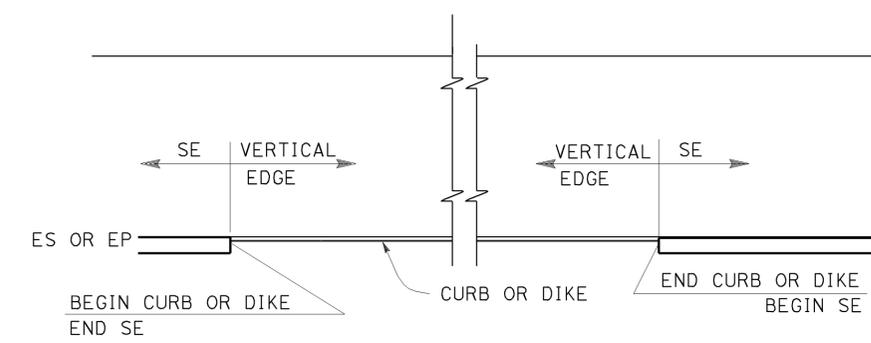


CURB OR DIKE

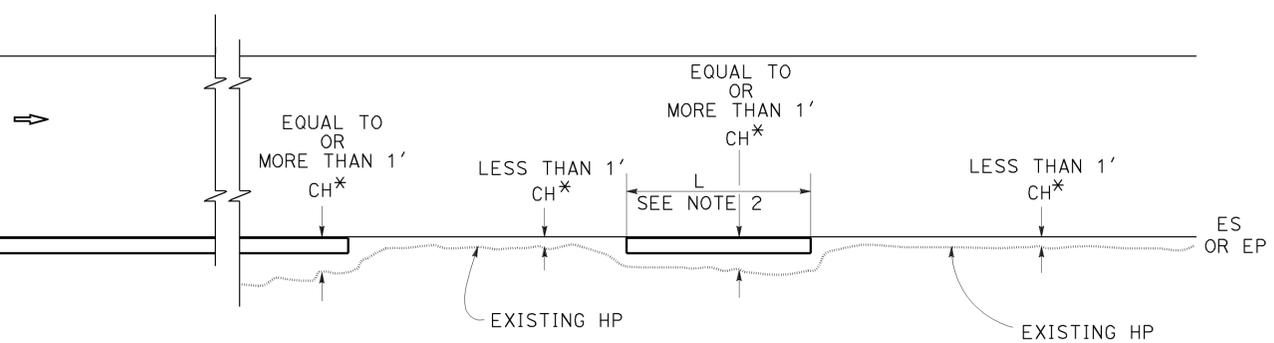


NARROW SIDE SLOPE

* CH = Distance from ES or EP to existing HP.

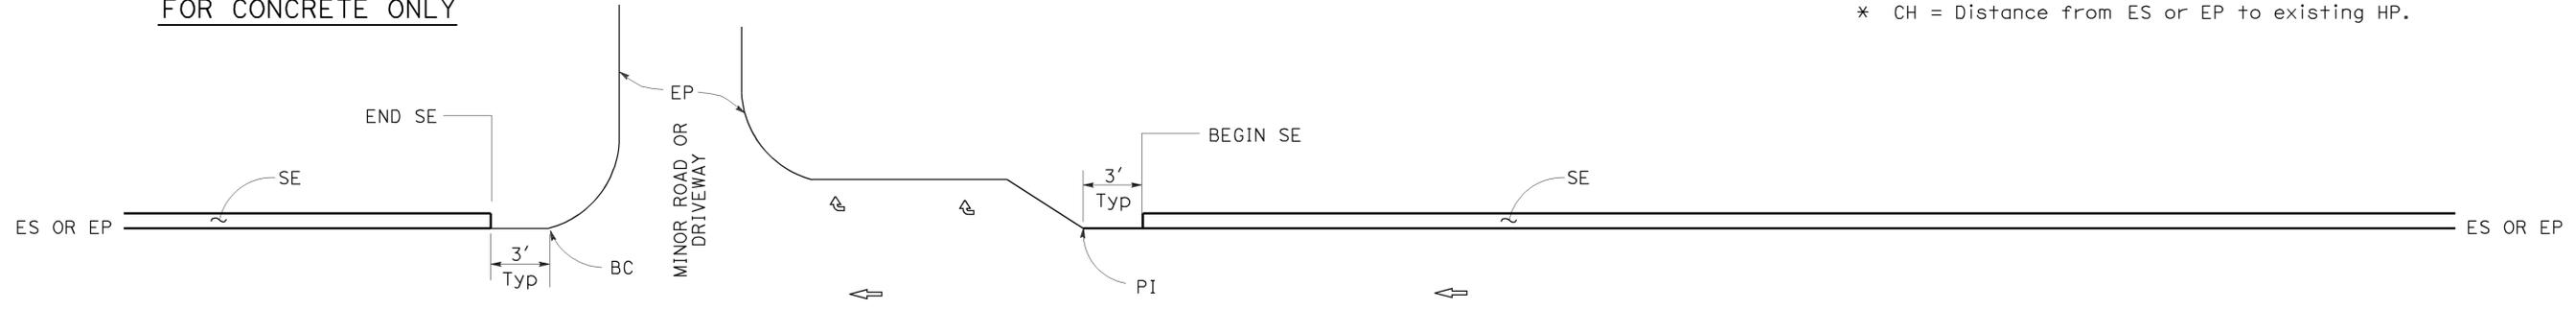

STATE ROUTE

STATE ROUTE

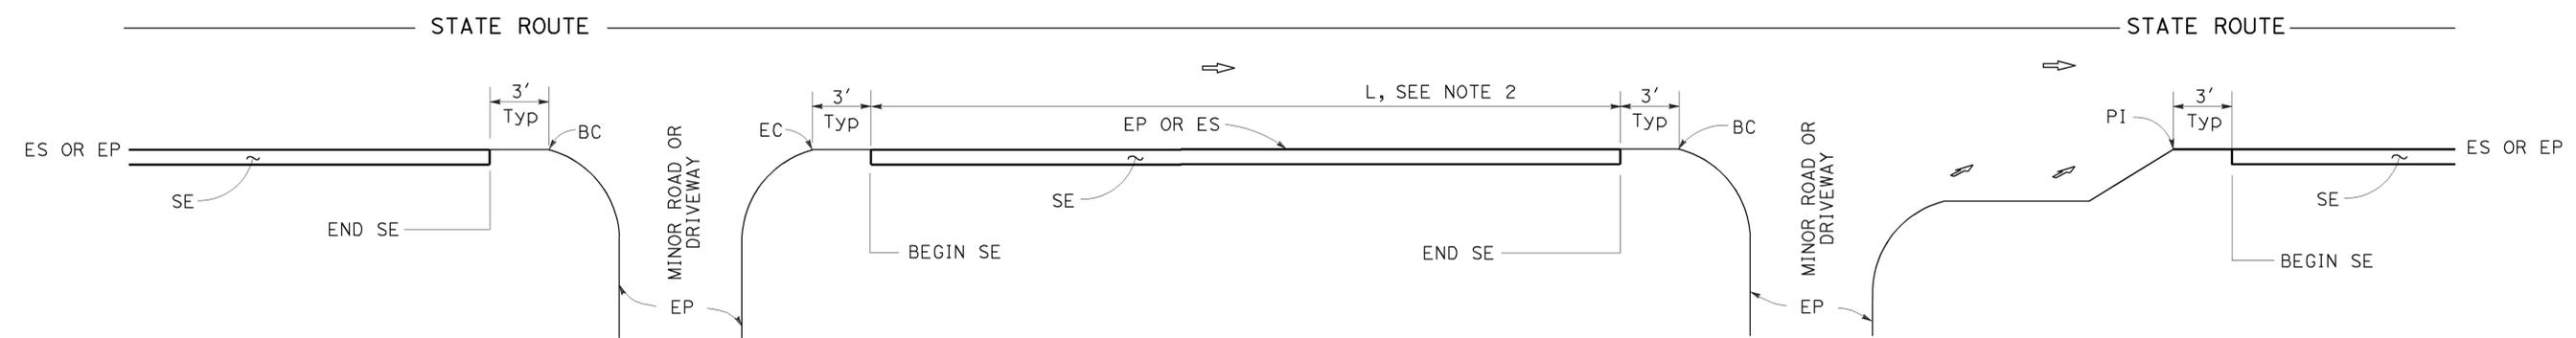

INTERSECTION

DRIVEWAY AND INTERSECTION

MINOR ROADWAY OR DRIVEWAY

STATE OF CALIFORNIA
DEPARTMENT OF TRANSPORTATION

PAVEMENT EDGE TREATMENTS

NO SCALE


- NOTES:**
1. For details not shown, see Revised Standard Plans RSP P75 and RSP P76.
 2. Safety edge is optional when L is less than 30'.

RSP P74 DATED NOVEMBER 15, 2013 SUPERSEDES RSP P74 DATED JANUARY 20, 2012 THAT SUPPLEMENTS THE STANDARD PLANS BOOK DATED 2010.


REVISED STANDARD PLAN RSP P74

2010 REVISED STANDARD PLAN RSP P74


2010 REVISED STANDARD PLAN RSP P75

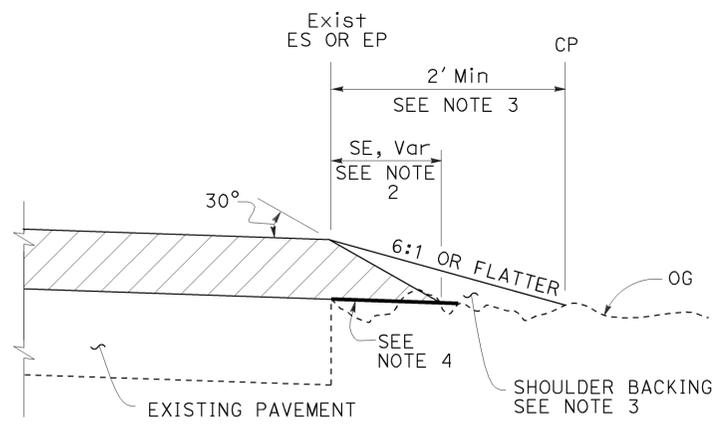


CASE A
Safety Edge

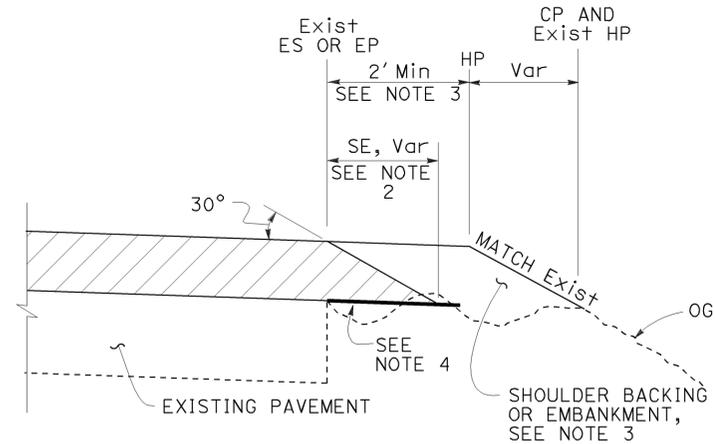


CASE B
Safety Edge

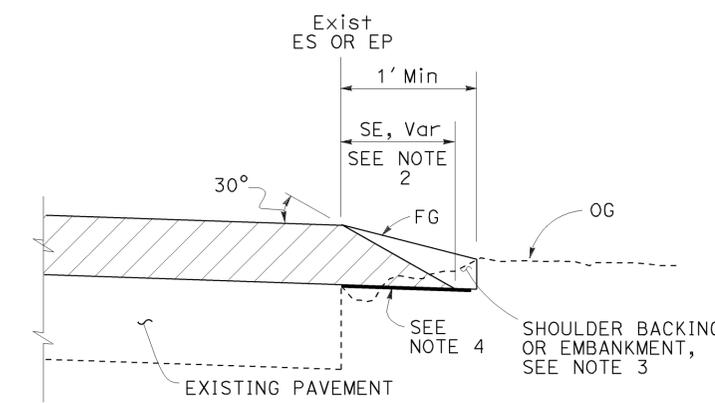


CASE C
Safety Edge

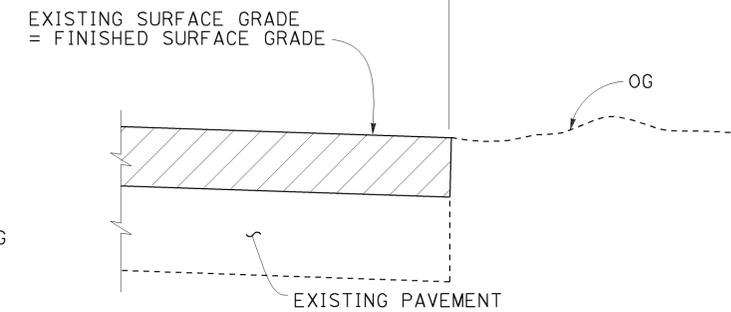

CASE D
Vertical Edge

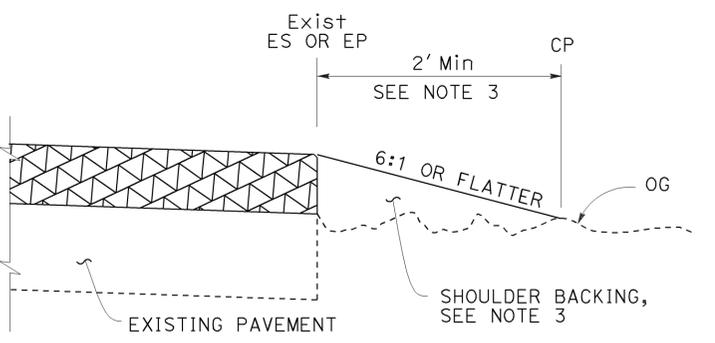

CASE E
Vertical Edge

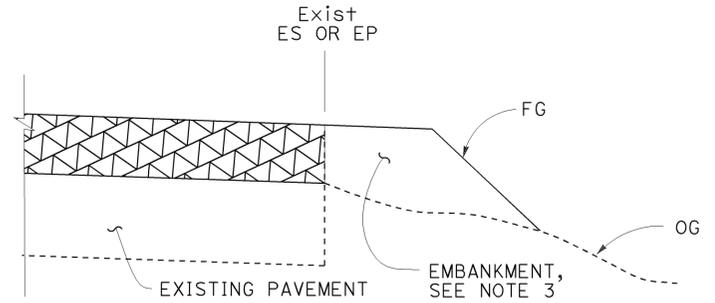

CASE F
Vertical Edge
* See Table A and Revised Std Plan RSP P74

- NOTES:**
- For limits of safety edge and vertical edge treatments, see Revised Standard Plan RSP P74.
 - Details shown for HMA overlay thickness less than 0.43'. See Detail "A" for HMA overlay thickness more than 0.43' or concrete overlay.
 - For locations and limits of shoulder backing or embankment see project plans.
 - Grade existing ground to place safety edge. 1' minimum width
 - Safety edge transverse joint must match overlay transverse joint. End of #6 longitudinal bar must be 2" ± 1/2" clear from transverse joint.
 - Safety edge is not needed in the area of MGS, barrier, right turn lane and acceleration lane. See Revised Standard Plan RSP P74.

LEGEND:

- HMA OVERLAY
- HMA OR CONCRETE OVERLAY
- CONCRETE OVERLAY

ABBREVIATIONS:

SE SAFETY EDGE
TT TOTAL THICKNESS OF SE


TABLE A
EDGE TREATMENT FOR VARIOUS OVERLAY THICKNESS AND CONDITIONS

FIELD CONDITION	OVERLAY THICKNESS	
	LESS THAN 0.15'	0.15' OR MORE
Exist SLOPE 6:1 OR FLATTER	CASE E	CASE A
Exist SLOPE 3:1 TO 6:1	CASE E	CASE B
Exist SLOPE STEEPER THAN 3:1	CASE F	CASE F
CUT SECTION (REPLACE, COLD PLANE, MILL PAVEMENT)	CASE D	CASE C


ADDITIONAL HMA OR CONCRETE QUANTITIES FOR SE/SIDE/MILE

TYPICAL CROSS SECTION	TT	TOTAL ADDITIONAL MATERIAL FOR SE/SIDE/MILE		
		HMA (TON)	CONCRETE (CY)*	CONCRETE (CY)**
	0.15'	NA	NA	NA
	0.20'	13.7	NA	NA
	0.30'	30.9	NA	NA
	0.40'	54.9	NA	NA
	0.45'	69.4	NA	NA
	0.50'	84.2	NA	NA
	0.60'	113.9	NA	NA
	0.70'	143.6	70.9	94.2
	0.80'	173.3	85.6	112.2
	0.90'	203.0	100.3	130.2
	1.00'	232.7	114.9	148.2
	1.20'	292.1	144.3	184.2

* For Detail "A"
** For Optional Detail "A"

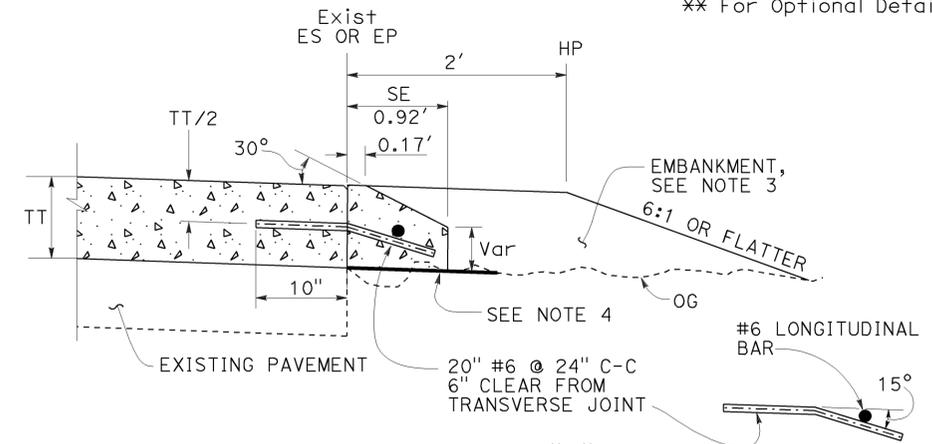

OPTIONAL DETAIL "A"
For concrete overlay
See Note 5

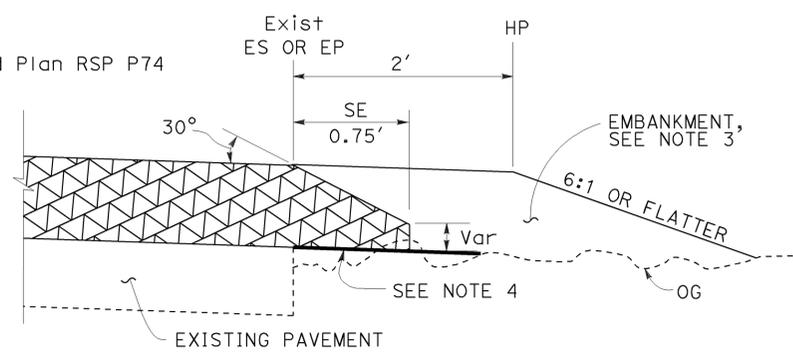

DETAIL "A"
For HMA overlay thickness more than 0.43' or concrete overlay

STATE OF CALIFORNIA
DEPARTMENT OF TRANSPORTATION
PAVEMENT EDGE TREATMENTS - OVERLAYS
NO SCALE

NOTES:

See Revised Standard Plan RSP T9 for tables.


Use cone spacing X for taper segment, Y for tangent segment or Z for conflict situations, as appropriate, per Table 1, unless X, Y, or Z cone spacing is shown on this sheet.

Unless otherwise specified in the special provisions, all temporary warning signs shall have black legend on fluorescent orange background.

California codes are designated by (CA). Otherwise, Federal (MUTCD) codes are shown.


TYPICAL LANE CLOSURE WITH REVERSIBLE CONTROL

TO ACCOMPANY PLANS DATED 2-2-15

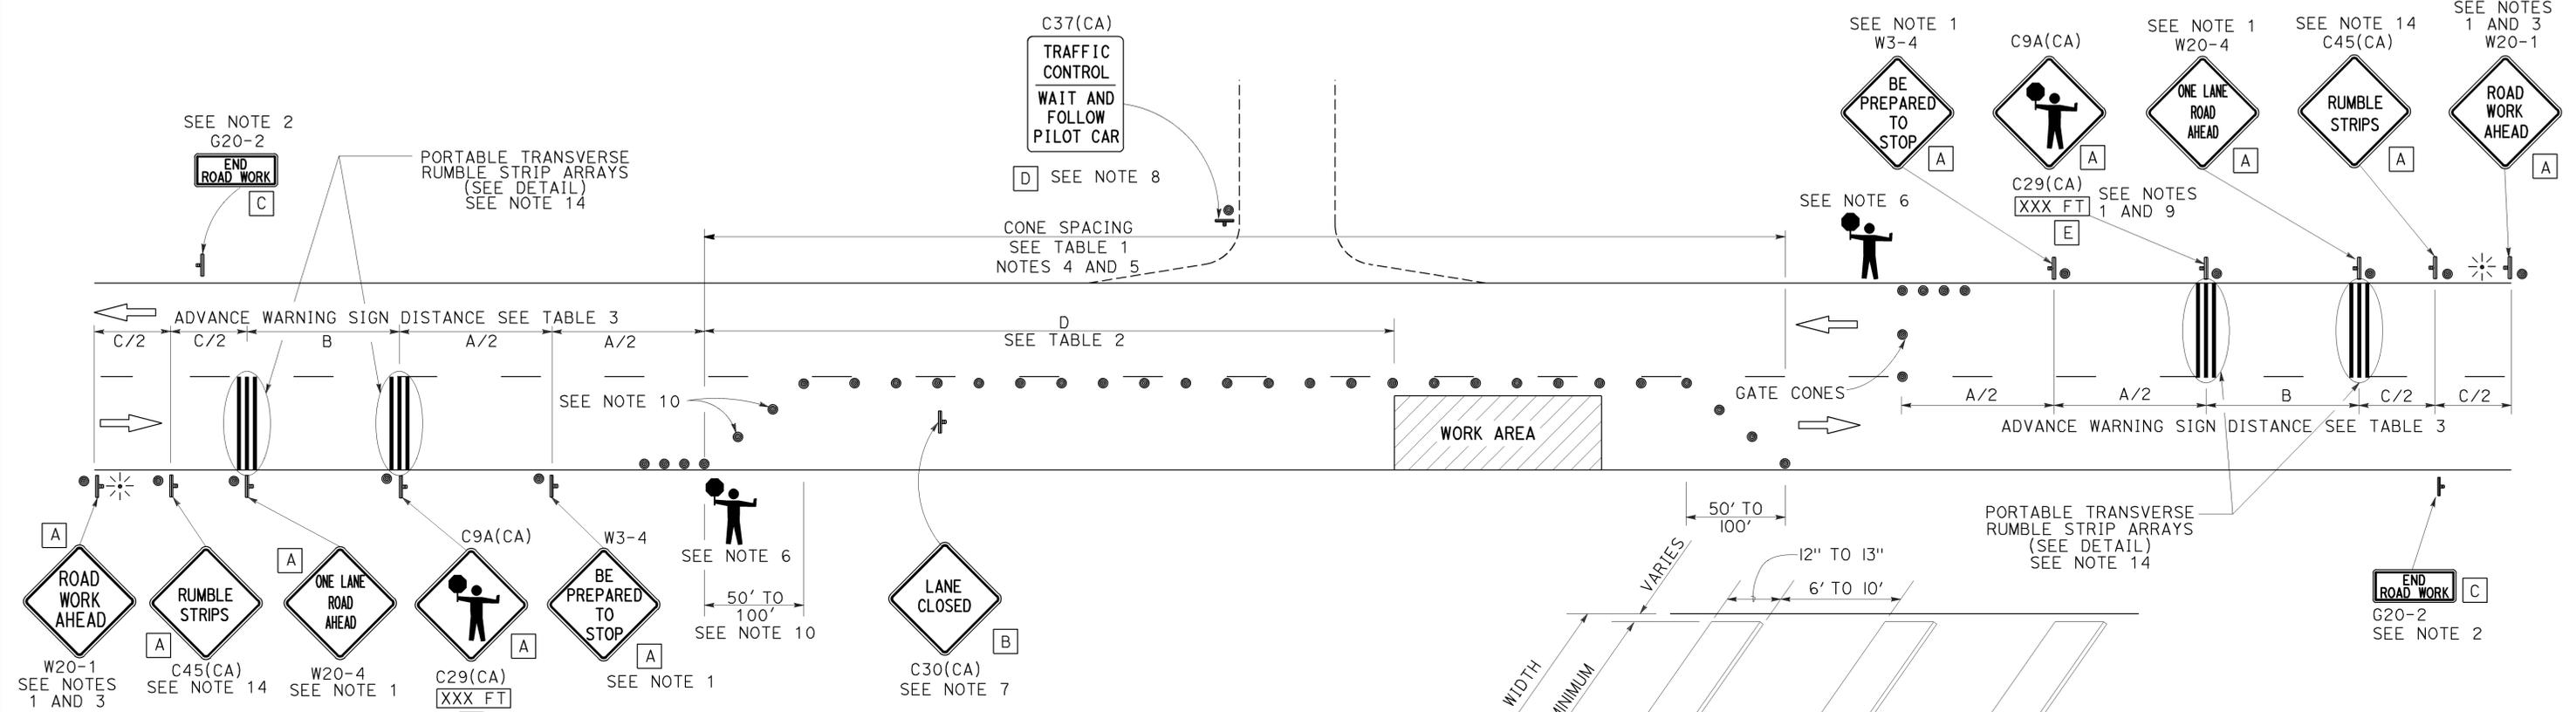

- NOTES:**
- Each advance warning sign in each direction of travel shall be equipped with at least two flags for daytime closure. Each flag shall be at least 16" x 16" in size and shall be orange or fluorescent red-orange in color. Flashing beacons shall be placed at the locations indicated for lane closure during hours of darkness.
 - A G20-2 "END ROAD WORK" sign, as appropriate, shall be placed at the end of the lane control unless the end of work area is obvious, or ends within a larger project's limits.
 - If the W20-1 sign would follow within 2000' of a stationary W20-1 or G20-1 "ROAD WORK NEXT _____ MILES", use a W20-4 sign for the first advance warning sign.
 - All cones used for lane closures during the hours of darkness shall be fitted with retroreflective bands (or sleeves) as specified in the specifications.
 - Portable delineators, placed at one-half the spacing indicated for traffic cones, may be used instead of cones for daytime closures only.
 - Additional advance flaggers may be required. Flagger should stand in a conspicuous place, be visible to approaching traffic as well as approaching vehicles after the first vehicle has stopped. During the hours of darkness, the flagging-station and flagger shall be illuminated and clearly visible to approaching traffic. The illumination footprint of the lighting on the ground shall be at least 20' in diameter. Place a minimum of four cones at 50' intervals in advance of flagger station as shown.

- Place C30(CA) "LANE CLOSED" sign at 500' to 1000' intervals throughout extended work areas. They are optional if the work area is visible from the flagger station.
- When a pilot car is used, place a C37(CA) "TRAFFIC CONTROL-WAIT AND FOLLOW PILOT CAR" sign with black legend on white background at all intersections, driveways and alleys without a flagger within traffic control area. Signs shall be clean and visible at all times. Where traffic can not be effectively self-regulated, at least one flagger shall be used at each intersection within traffic control area.
- An optional C29(CA) sign may be placed below the C9A(CA) sign.
- Either traffic cones or barricades shall be placed on the taper. Barricades shall be Type I, II, or III.
- The color of the portable transverse rumble strips shall be black or orange. Use 2 arrays, each array shall consist of 3 rumble strips.
- Portable transverse rumble strips shall not be placed on sharp horizontal or vertical curves nor shall they be placed through pedestrian crossings.
- If the portable transverse rumble strips become out of alignment (skewed) by more than 6 inches, measured from one end to the other, they shall be readjusted to bring the placement back to the original location.
- Portable transverse rumble strips are not required if any one of the following conditions is satisfied:
 - Work duration occupies a location for four hours or less
 - Posted speed limit is below 45 MPH
 - Work is of emergency nature
 - Work zone is in snow or icy weather conditions

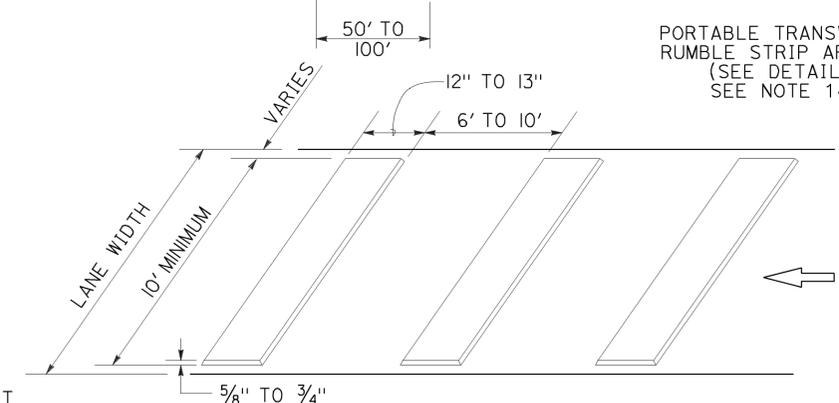

SIGN PANEL SIZE (Min)

- A 48" x 48"
- B 30" x 30"
- C 36" x 18"
- D 36" x 42"
- E 20" x 7"

LEGEND

- TRAFFIC CONE
- ⊥ TEMPORARY TRAFFIC CONTROL SIGN
- ⚡ PORTABLE FLASHING BEACON
- 🚧 FLAGGER

STATE OF CALIFORNIA
DEPARTMENT OF TRANSPORTATION


**TRAFFIC CONTROL SYSTEM
FOR LANE CLOSURE ON
TWO LANE CONVENTIONAL
HIGHWAYS**

NO SCALE

RSP T13 DATED OCTOBER 17, 2014 SUPERSEDES RSP T13 DATED JULY 18, 2014
AND RSP T13 DATED APRIL 19, 2013 AND STANDARD PLAN T13 DATED
MAY 20, 2011 - PAGE 241 OF THE STANDARD PLANS BOOK DATED 2010.

2010 REVISED STANDARD PLAN RSP T13

TO ACCOMPANY PLANS DATED 2-2-15

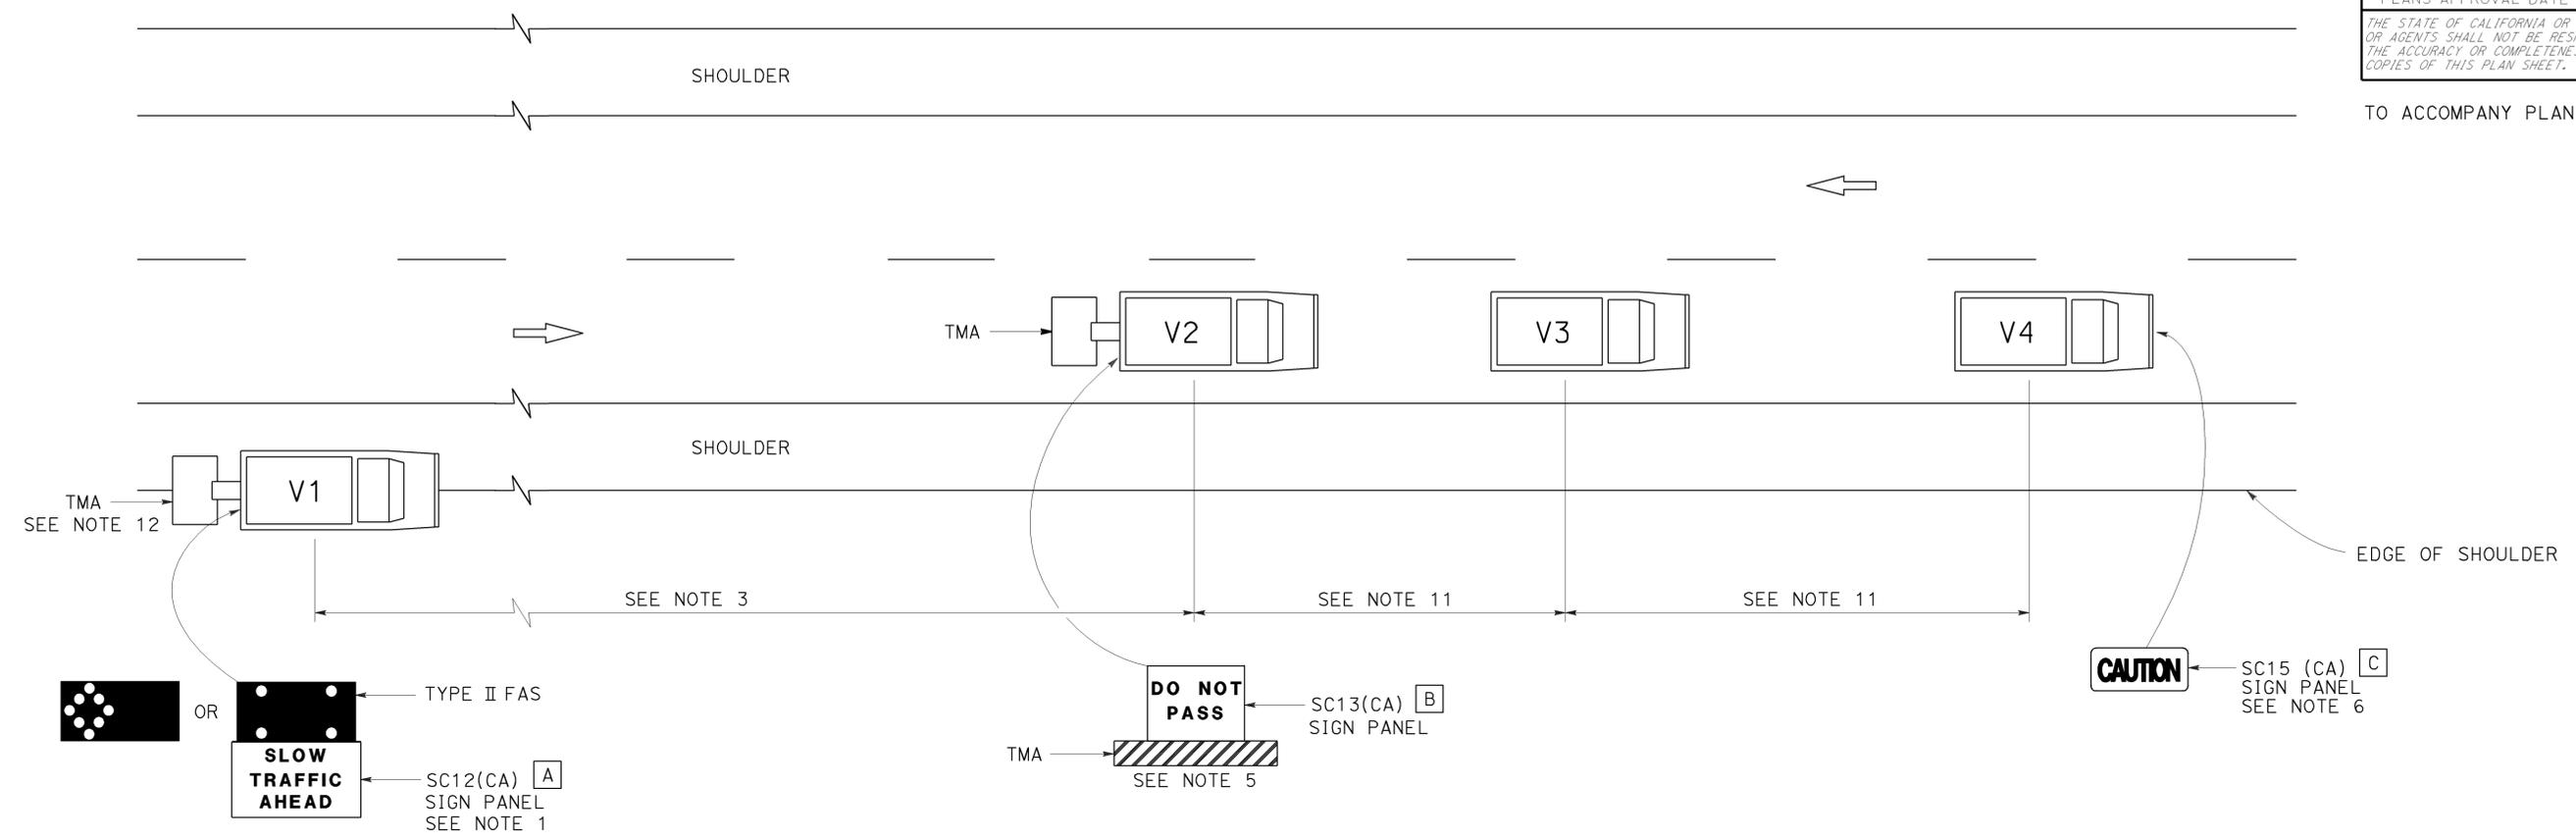

NOTES:

1. Either a changeable message sign or a SC12(CA) "SLOW TRAFFIC AHEAD" sign shall be mounted on the rear of sign vehicle V1. The changeable message sign shall be sequenced to show the "CAUTION" message first, follow by the "SLOW TRAFFIC AHEAD" message. A Type II flashing arrow sign may be used with the SC12(CA) sign panel.
2. Sign vehicle V1 should be positioned where highly visible when shoulders are not available.
3. If traffic queues develop, sign vehicle V1 should be positioned upstream from the end of queue.
4. Vehicle-mounted sign panels shall have Type III or above retroreflective sheeting, black on white, or black on fluorescent orange, with 6" minimum series D letters per Caltrans sign specifications.
5. Shadow vehicle shall be equipped with a truck-mounted attenuator. The sign panel shown shall be mounted on the rear of shadow vehicle V2. The message "LANE CLOSED" may be used in place of the "DO NOT PASS" message.
6. The sign panel shown shall be mounted on the front of sign vehicle V4, facing opposing traffic.

7. All vehicles shall be equipped with flashing or rotating amber lights.
8. Sign vehicle V4 will not be required when the work and vehicles V2 and V3 are 2' or more from the centerline of the highway during the work or application operations.
9. All vehicles used for lane closures shall be equipped with two-way radios and the vehicle operators shall maintain communication during the work or application operation.
10. This plan shall not be used where workers would be on foot in the work area. Use a stationary type lane closure (Revised Standard Plan T13) for this condition.
11. Minimize spacing between vehicles V2 and V3 and vehicles V3 and V4 to deter road users from driving in between them.
12. If sign vehicle V1 encroaches into the traffic lane due to insufficient shoulder width, sign vehicle V1 shall be equipped with a truck-mounted attenuator. Sign vehicle V1 shall stay as close to the edge of shoulder as practicable.

LEGEND

- V1 SIGN VEHICLE
- V2 SHADOW VEHICLE
- V3 WORK/APPLICATION VEHICLE
- V4 SIGN VEHICLE
- TMA TRUCK-MOUNTED ATTENUATOR
-  FLASHING ARROW SIGN (FAS) IN FLASHING CAUTION MODE
-  FLASHING ARROW SIGN (FAS) IN ALTERNATING DIAMOND CAUTION

SIGN PANEL SIZE (Min)

- A 72" x 42"
- B 54" x 42"
- C 54" x 24"

STATE OF CALIFORNIA
 DEPARTMENT OF TRANSPORTATION
**TRAFFIC CONTROL SYSTEM
 FOR MOVING LANE CLOSURE
 ON TWO LANE HIGHWAYS**
 NO SCALE

RSP T17 DATED APRIL 19, 2013 SUPERSEDES STANDARD PLAN T17
 DATED MAY 20, 2011 - PAGE 245 OF THE STANDARD PLANS BOOK DATED 2010.

REVISED STANDARD PLAN RSP T17

2010 REVISED STANDARD PLAN RSP T17

LEGEND:

AB	ABANDON. IF APPLIED TO CONDUIT, REMOVE CONDUCTORS
BC	INSTALL PULL BOX IN EXISTING CONDUIT RUN
BP	PEDESTRIAN BARRICADE, TYPE AS INDICATED ON PLAN
CB	INSTALL CONDUIT INTO EXISTING PULL BOX
CC	CONNECT NEW AND EXISTING CONDUIT. REMOVE EXISTING CONDUCTORS AND INSTALL CONDUCTORS AS INDICATED
CF	CONDUIT TO REMAIN FOR FUTURE USE. REMOVE CONDUCTORS. INSTALL PULL TAPE
DH	DETECTOR HANDHOLE
FA	FOUNDATION TO BE ABANDONED
IS	INSTALL SIGN ON SIGNAL MAST ARM
NS	NO SLIP BASE ON STANDARD
PEC	PHOTOELECTRIC CONTROL
PEU	PHOTOELECTRIC UNIT
RC	EQUIPMENT OR MATERIAL TO BE REMOVED AND BECOME THE PROPERTY OF THE CONTRACTOR
RE	REMOVE ELECTROLIER, FUSES AND BALLAST. TAPE ENDS OF CONDUCTORS
RL	RELOCATE EQUIPMENT
RR	REMOVE AND REUSE EQUIPMENT
RS	REMOVE AND SALVAGE EQUIPMENT
SC	SPLICE NEW TO EXISTING CONDUCTORS
SD	SERVICE DISCONNECT
TSP	TELEPHONE SERVICE POINT

ABBREVIATIONS

APS	ACCESSIBLE PEDESTRIAN SIGNAL	M/M	MULTIPLE TO MULTIPLE TRANSFORMER
BBS	BATTERY BACKUP SYSTEM	Mtg	MOUNTING
BC	BOLT CIRCLE	MV	MERCURY VAPOR LIGHTING FIXTURE
BPB	BICYCLE PUSH BUTTON	MVDS	MICROWAVE VEHICLE DETECTION SYSTEM
C	CONDUIT	N	NEUTRAL (GROUNDED CONDUCTOR)
CB	CIRCUIT BREAKER	NB	NEUTRAL BUS
CCTV	CLOSED CIRCUIT TELEVISION	NC	NORMALLY CLOSE
Ck+	CIRCUIT	NO	NORMALLY OPEN
CMS	CHANGEABLE MESSAGE SIGN	P	CIRCUIT BREAKER'S POLE
Ctid	CALTRANS IDENTIFICATION	PB	PULL BOX
Comm	COMMUNICATION	PBA	PUSH BUTTON ASSEMBLY
DLC	LOOP DETECTOR LEAD-IN CABLE	PEC	PHOTOELECTRIC CONTROL
EMS	EXTINGUISHABLE MESSAGE SIGN	Ped	PEDESTRIAN
EVUC	EMERGENCY VEHICLE UNIT CABLE	PEU	PHOTOELECTRIC UNIT
EVUD	EMERGENCY VEHICLE UNIT DETECTOR	PT	CONDUIT WITH PULL TAPE
FB	FLASHING BEACON	RE	RELOCATED EQUIPMENT
FBCA	FLASHING BEACON CONTROL ASSEMBLY	RM	RAMP METERING
FBS	FLASHING BEACON WITH SLIP BASE	RWIS	ROADSIDE WEATHER INFORMATION SYSTEM
FO	FIBER OPTIC	SB	SLIP BASE
G	EQUIPMENT GROUNDING CONDUCTOR	SIC	SIGNAL INTERCONNECT CABLE
GB	GROUND BUS	Sig	SIGNAL
GFCI	GROUND FAULT CIRCUIT INTERRUPTER	SMA	SIGNAL MAST ARM
HAR	HIGHWAY ADVISORY RADIO	SNS	STREET NAME SIGN
Hex	HEXAGONAL	SP	SERVICE POINT
HPS	HIGH PRESSURE SODIUM	TDC	TELEPHONE DEMARCATION CABINET
IISNS	INTERNALLY ILLUMINATED STREET NAME SIGN	TMS	TRAFFIC MONITORING STATION
ISL	INDUCTION SIGN LIGHTING	TOS	TRAFFIC OPERATIONS SYSTEM
LED	LIGHT EMITTING DIODE	Veh	VEHICLE
LMA	LUMINAIRE MAST ARM	VIVDS	VIDEO IMAGE VEHICLE DETECTION SYSTEM
LPS	LOW PRESSURE SODIUM	WIM	WEIGH-IN-MOTION
Ltg	LIGHTING	Xfmr	TRANSFORMER
Lum	LUMINAIRE		
M	METERED		
MAT	MAST ARM MOUNTING TOP ATTACHMENT		
MAS	MAST ARM MOUNTING SIDE ATTACHMENT		

Dist	COUNTY	ROUTE	POST MILES TOTAL PROJECT	SHEET No.	TOTAL SHEETS
10	SJ	4	0.0/4.34.4/5.4 6.9/8.3	20	24

Theresa Gabriel
REGISTERED ELECTRICAL ENGINEER

July 19, 2013
PLANS APPROVAL DATE

Theresa Aziz Gabriel
No. E15129
Exp. 6-30-14
ELECTRICAL
STATE OF CALIFORNIA

THE STATE OF CALIFORNIA OR ITS OFFICERS OR AGENTS SHALL NOT BE RESPONSIBLE FOR THE ACCURACY OR COMPLETENESS OF SCANNED COPIES OF THIS PLAN SHEET.

TO ACCOMPANY PLANS DATED 2-2-15

SOFFIT AND WALL MOUNTED LUMINAIRES

- PENDANT, 70 W HPS UNLESS OTHERWISE SPECIFIED
- FLUSH, 70 W HPS UNLESS OTHERWISE SPECIFIED
- WALL SURFACE, 70 W HPS UNLESS OTHERWISE SPECIFIED
- EXISTING SOFFIT OR WALL LUMINAIRE TO REMAIN UNMODIFIED
- EXISTING SOFFIT OR WALL LUMINAIRE TO BE MODIFIED AS SPECIFIED

NOTE:
Arrow indicates "street side" of luminaire.

COMMONLY USED SYMBOLS FOR UNITED STATES CUSTOMARY UNITS OF MEASUREMENT:

SYMBOL USED	DEFINITIONS
Ω	OHMS
min	MINUTE
s	SECOND
bps	BITS PER SECOND
Bps	BYTES PER SECOND
A	AMPERE
V	VOLT
V(ac)	VOLT (DIRECT CURRENT)
V(ac)	VOLT (ALTERNATING CURRENT)
FC	FOOT - CANDLE
W	WATTS
VA	VOLT-AMPERE
M	MEGA
k	KILO
m	MILLI
μ	MICRO
P	PICO
Hz	HERTZ

MISCELLANEOUS ELECTROLIERS

NEW	EXISTING	
		LUMINAIRE ON WOOD POLE
		NON-STANDARD ELECTROLIER (SEE PROJECT NOTES OR PROJECT PLANS)
		CITY ELECTROLIER
		ELECTROLIER FOUNDATION (FUTURE INSTALLATION)

- NOTES:**
- HPS luminaires shall be 310 W HPS when installed on Type 21, 21D, 30, 31 and 32 Standards, unless otherwise specified. HPS luminaires shall be 200 W when installed on other type standards or poles, unless otherwise specified.
 - LED luminaires shall be 235 W when installed on Type 21, 21D, 30, 31 and 32 Standards, unless otherwise specified. LED luminaires shall be 165 W when installed on other type standards or poles, unless otherwise specified.
 - Luminaires shall be the cutoff type, ANSI Type III medium cutoff lighting distribution, unless otherwise specified.

STANDARD ELECTROLIER

NEW	EXISTING	STANDARD TYPE
		15
		15D
		15 STRUCTURE
		15D STRUCTURE
		21
		21D
		21 STRUCTURE
		21D STRUCTURE
		30
		31
		32

STATE OF CALIFORNIA
DEPARTMENT OF TRANSPORTATION

ELECTRICAL SYSTEMS (LEGEND AND ABBREVIATIONS)

NO SCALE

RSP ES-1A DATED JULY 19, 2013 SUPERSEDES STANDARD PLAN ES-1A DATED MAY 20, 2011 - PAGE 425 OF THE STANDARD PLANS BOOK DATED 2010.

2010 REVISED STANDARD PLAN RSP ES-1A

Dist	COUNTY	ROUTE	POST MILES TOTAL PROJECT	SHEET No.	TOTAL SHEETS
10	SJ	4	0.0/4.34.4/5.4 6.9/8.3	21	24

Theresa Gabriel
 REGISTERED ELECTRICAL ENGINEER
 July 19, 2013
 PLANS APPROVAL DATE

Theresa Aziz Gabriel
 No. E15129
 Exp. 6-30-14
 ELECTRICAL
 STATE OF CALIFORNIA

THE STATE OF CALIFORNIA OR ITS OFFICERS OR AGENTS SHALL NOT BE RESPONSIBLE FOR THE ACCURACY OR COMPLETENESS OF SCANNED COPIES OF THIS PLAN SHEET.

TO ACCOMPANY PLANS DATED 2-2-15

CONDUIT

NEW	EXISTING	
---	---	LIGHTING CONDUIT, UNLESS OTHERWISE INDICATED OR NOTED
---	---	TRAFFIC SIGNAL CONDUIT
---C---	---c---	COMMUNICATION CONDUIT
---T---	---t---	TELEPHONE CONDUIT
---F---	---f---	FIRE ALARM CONDUIT
---FO---	---fo---	FIBER OPTIC CONDUIT
---	---	CONDUIT TERMINATION
		CONDUIT RISER ATTACHED TO THE STRUCTURE OR SERVICE POLE

SIGNAL EQUIPMENT

NEW	EXISTING	
		PEDESTRIAN SIGNAL HEAD "C" INDICATES COUNTDOWN PEDESTRIAN HEAD
		PUSH BUTTON ASSEMBLY POST
		PEDESTRIAN BARRICADE
		VEHICLE SIGNAL HEAD (WITH BACKPLATE AND 3-SECTIONS: RED, YELLOW AND GREEN)
		VEHICLE SIGNAL HEAD WITH ANGLE VISOR
		MODIFICATIONS OF BASIC SYMBOL: "L" INDICATES ALL NON-ARROW SECTIONS LOUVERED "LG" INDICATES LOUVERED GREEN SECTION ONLY "PV" INDICATES ALL 12" SECTIONS PROGRAMMED VISIBILITY "8" INDICATES ALL 8" SECTIONS (ONLY WHEN SPECIFIED)
		VEHICLE SIGNAL HEAD CONSISTING OF RED, YELLOW AND GREEN LEFT ARROW SECTIONS
		VEHICLE SIGNAL HEAD CONSISTING OF RED AND YELLOW SECTIONS WITH AN UP GREEN ARROW SECTION
		VEHICLE SIGNAL HEAD (5 SECTION) CONSISTING OF RED, YELLOW AND GREEN SECTIONS WITH YELLOW AND GREEN RIGHT ARROW SECTIONS
		TYPE 15TS STANDARD WITH VEHICLE SIGNAL HEAD AND LUMINAIRE
		TYPE 21TS STANDARD WITH VEHICLE SIGNAL HEAD AND LUMINAIRE
		STANDARD WITH LUMINAIRE AND SIGNAL MAST ARMS AND ATTACHED VEHICLE SIGNAL HEADS
		TYPE 1 STANDARD WITH ATTACHED VEHICLE SIGNAL HEADS
		STANDARD WITH A SIGNAL MAST ARM, ATTACHED VEHICLE SIGNAL HEADS AND INTERNALLY ILLUMINATED STREET NAME SIGN
		CONTROLLER ASSEMBLY. DOOR INDICATES FRONT OF CABINET

SERVICE EQUIPMENT

NEW	EXISTING	
---OH---	---oh---	OVERHEAD LINES
		WOOD POLE, "U" INDICATES UTILITY OWNED
		POLE GUY WITH ANCHOR
		UTILITY TRANSFORMER - GROUND MOUNTED
		SERVICE EQUIPMENT ENCLOSURE TYPE. DOOR INDICATES FRONT OF ENCLOSURE
		TELEPHONE DEMARCATION CABINET

POLE-MOUNTED SERVICE DESIGNATION

	TYPE H SERVICE, 28'-10"	TYPE OF INSTALLATION AND POLE HEIGHT ABOVE GRADE
--	-------------------------	--

FLASHING BEACON

NEW	EXISTING	
		FLASHING BEACON (ONE VEHICLE SIGNAL HEAD WITH BACKPLATE AND VISOR) "R" INDICATES RED INDICATION, "Y" INDICATES YELLOW INDICATION
		FLASHING BEACON WITH TYPE 15-FBS STANDARD AND A SIGN.
		FLASHING BEACON WITH TYPES 9, 9A OR 9B SIGN UNLESS OTHERWISE SPECIFIED OR INDICATED

SIGNAL EQUIPMENT Cont

NEW	EXISTING	
		GUARD POST
		TYPE 1 STANDARD WITH RAMP METERING SIGN
		OPTICAL DETECTOR FOR THE EMERGENCY VEHICLE DETECTION SYSTEM

NOTES:

- All signal sections shall be 12" unless shown otherwise.
- Signal heads shall be provided with backplates unless shown otherwise.

ILLUMINATED OVERHEAD SIGN

NEW	EXISTING	
		SINGLE POST, SINGLE ILLUMINATED SIGN, BALANCED BUTTERFLY
		SINGLE POST, DOUBLE ILLUMINATED SIGN, BALANCED BUTTERFLY
		SINGLE POST, SINGLE ILLUMINATED SIGN, FULL CANTILEVER
		DOUBLE POST, SINGLE ILLUMINATED SIGN
		SINGLE ILLUMINATED SIGN MOUNTED ON STRUCTURE
		DOUBLE POST, SINGLE ILLUMINATED SIGN WITH ELECTROLIER

STATE OF CALIFORNIA
DEPARTMENT OF TRANSPORTATION

**ELECTRICAL SYSTEMS
(LEGEND AND ABBREVIATIONS)**

NO SCALE


RSP ES-1B DATED JULY 19, 2013 SUPERSEDES STANDARD PLAN ES-1B DATED MAY 20, 2011 - PAGE 426 OF THE STANDARD PLANS BOOK DATED 2010.

REVISED STANDARD PLAN RSP ES-1B


2010 REVISED STANDARD PLAN RSP ES-1B

EQUIPMENT IDENTIFICATION


ILLUMINATED SIGN IDENTIFICATION NUMBER:

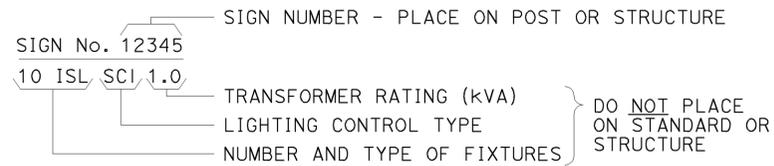


ELECTROLIER OR EQUIPMENT IDENTIFICATION NUMBER:

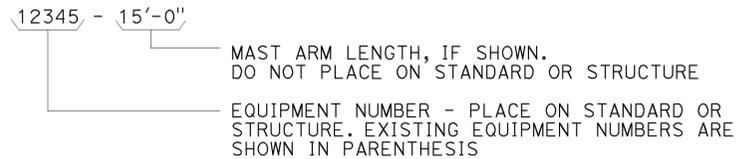


CONDUIT AND CONDUCTOR IDENTIFICATION:

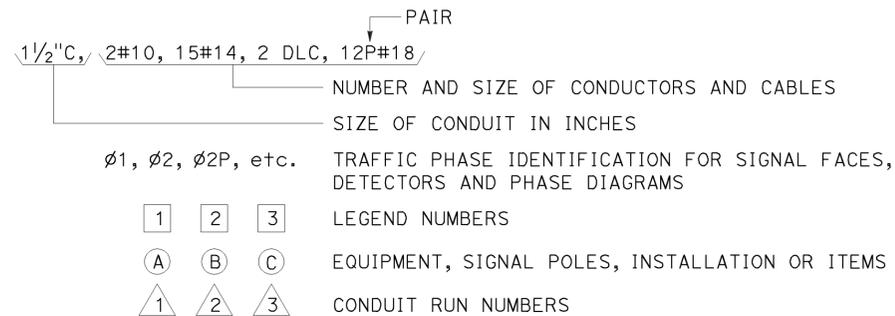


SIGNAL AND LIGHTING STANDARD (TYPICAL DESIGNATION):

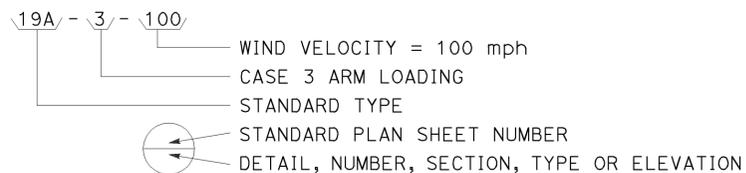


MISCELLANEOUS EQUIPMENT

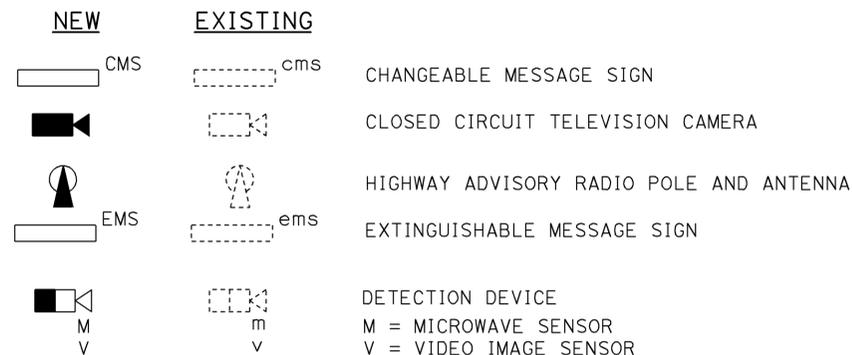



WIRING DIAGRAM LEGEND

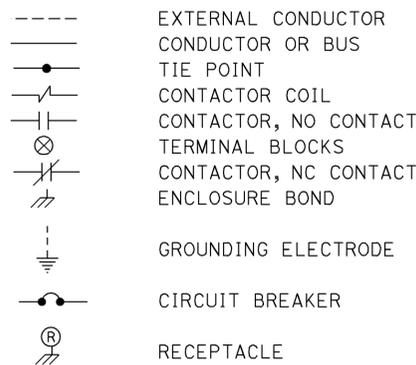

PULL BOXES

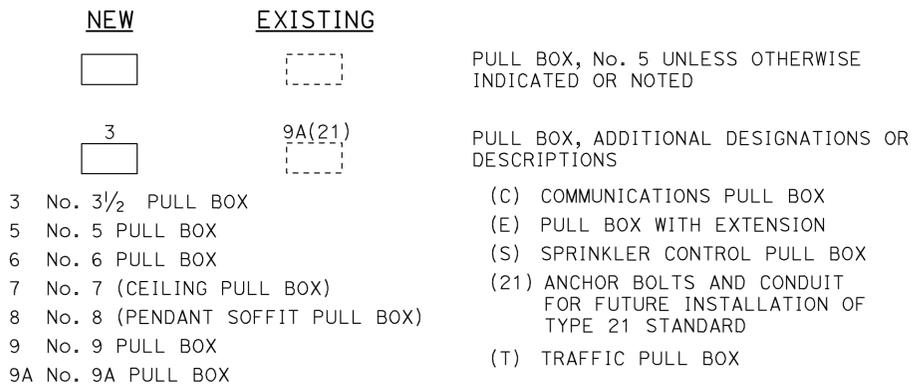

VEHICLE DETECTORS

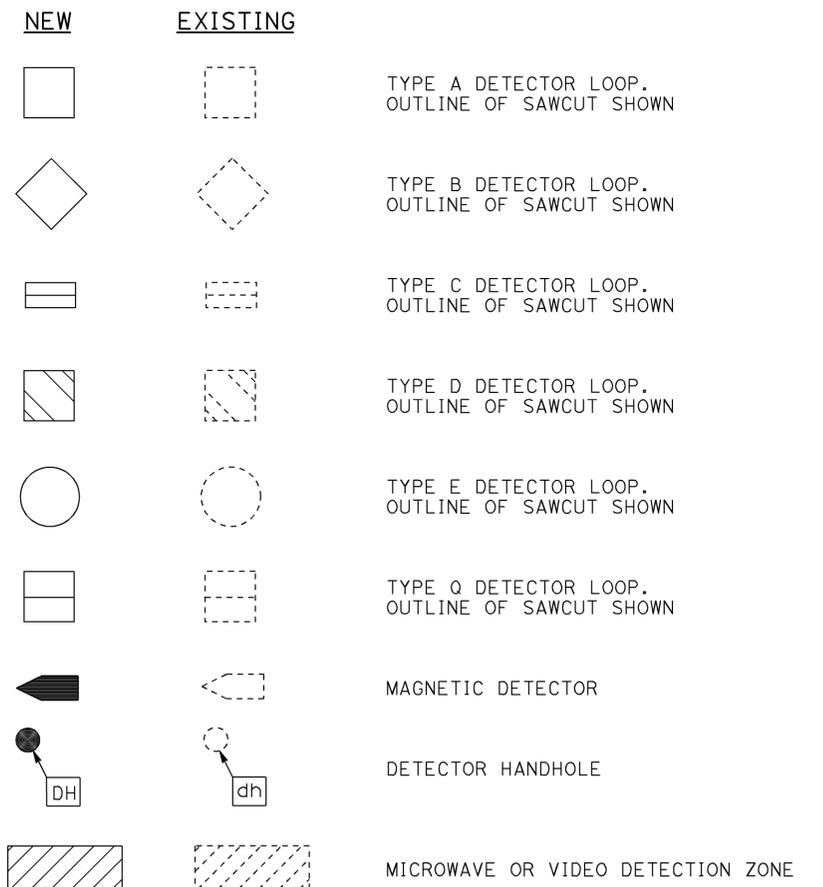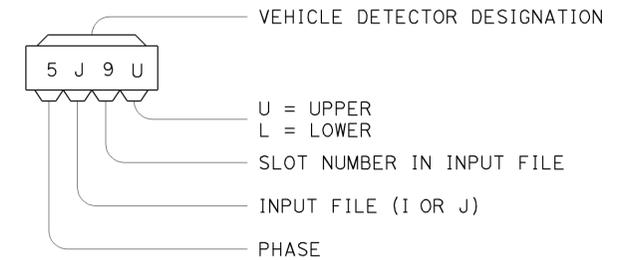

STATE OF CALIFORNIA
 DEPARTMENT OF TRANSPORTATION

ELECTRICAL SYSTEMS (LEGEND AND ABBREVIATIONS)

NO SCALE

RSP ES-1C DATED JULY 19, 2013 SUPERSEDES STANDARD PLAN ES-1C DATED MAY 20, 2011 - PAGE 427 OF THE STANDARD PLANS BOOK DATED 2010.


2010 REVISED STANDARD PLAN RSP ES-1C

Dist	COUNTY	ROUTE	POST MILES TOTAL PROJECT	SHEET No.	TOTAL SHEETS
10	SJ	4	0.0/4.34.4/5.4 6.9/8.3	23	24


Theresa Gabriel
 REGISTERED ELECTRICAL ENGINEER
 July 19, 2013
 PLANS APPROVAL DATE
 THE STATE OF CALIFORNIA OR ITS OFFICERS OR AGENTS SHALL NOT BE RESPONSIBLE FOR THE ACCURACY OR COMPLETENESS OF SCANNED COPIES OF THIS PLAN SHEET.

REGISTERED PROFESSIONAL ENGINEER
 Theresa Aziz Gabriel
 No. E15129
 Exp. 6-30-14
 ELECTRICAL
 STATE OF CALIFORNIA


TO ACCOMPANY PLANS DATED 2-2-15

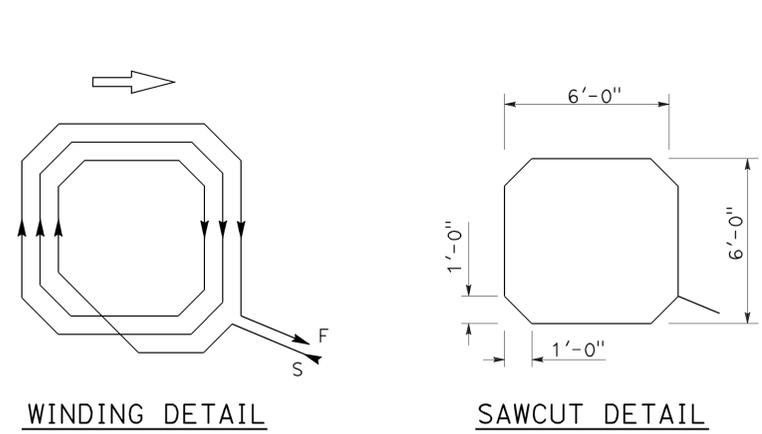


WINDING DETAIL
SAWCUT DETAIL
TYPE A LOOP DETECTOR CONFIGURATION

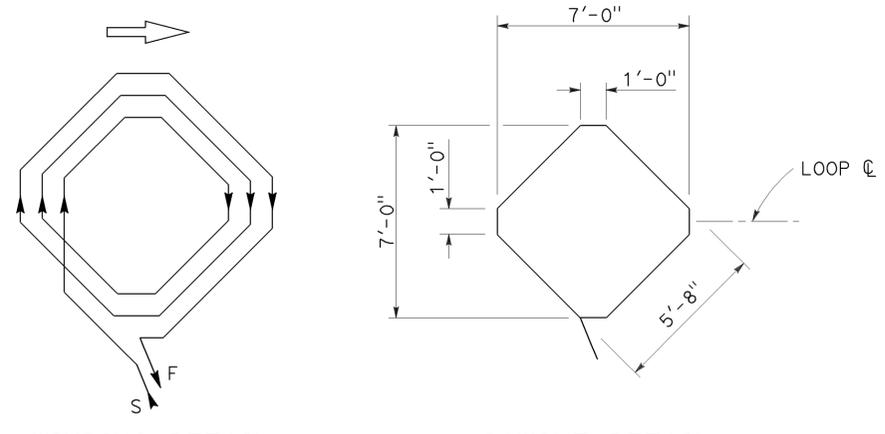


WINDING DETAIL
SAWCUT DETAIL
TYPE B LOOP DETECTOR CONFIGURATION

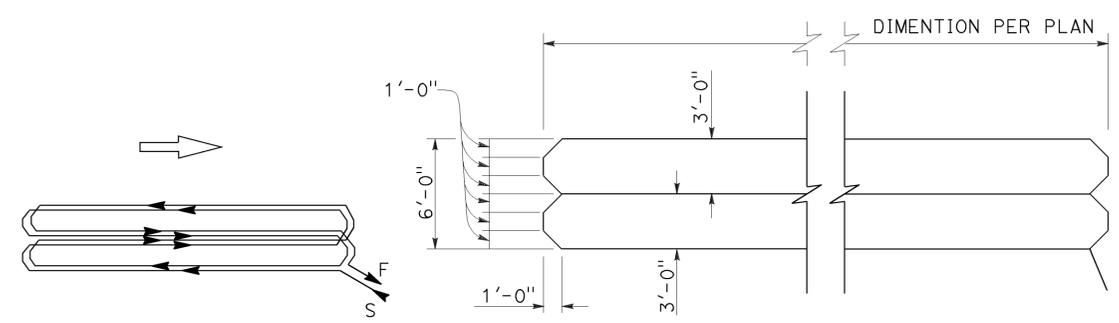


WINDING DETAIL
SAWCUT DETAIL
TYPE C LOOP DETECTOR CONFIGURATION

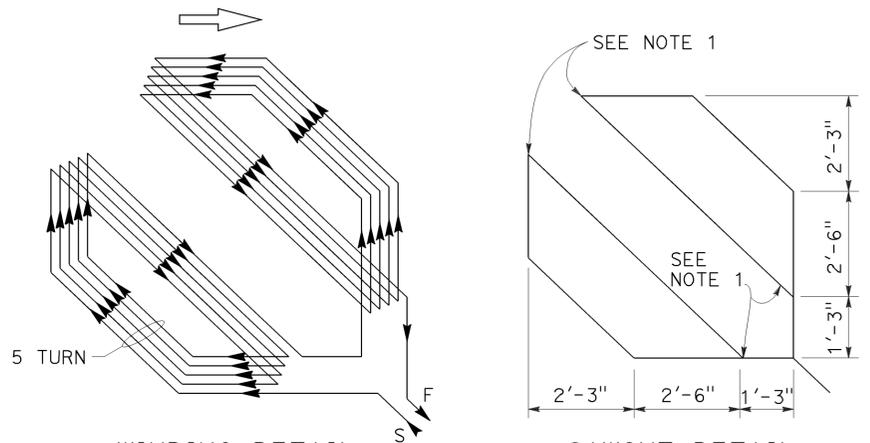


WINDING DETAIL
SAWCUT DETAIL
TYPE D LOOP DETECTOR CONFIGURATION

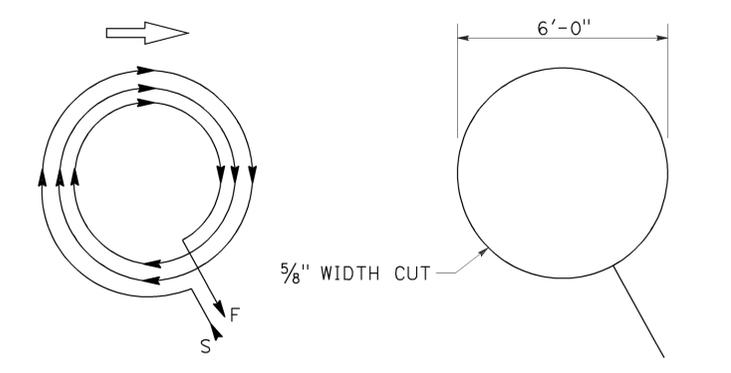

WINDING DETAIL
SAWCUT DETAIL
TYPE E LOOP DETECTOR CONFIGURATION

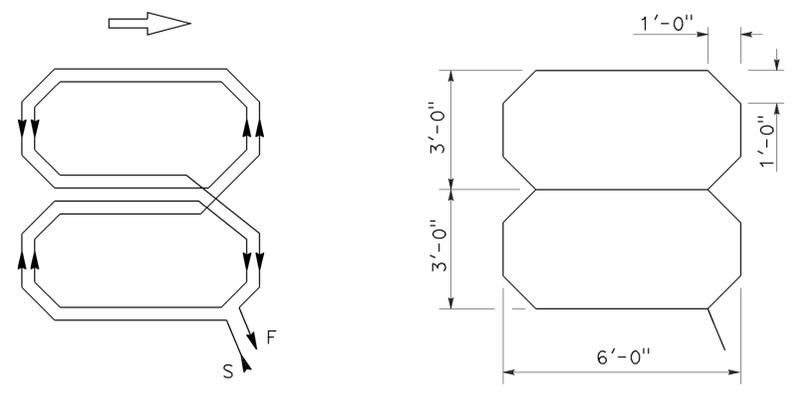

WINDING DETAIL
SAWCUT DETAIL
TYPE Q LOOP DETECTOR CONFIGURATION

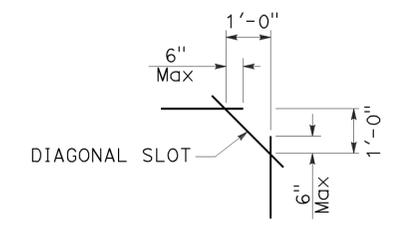

PLAN VIEW OF DIAGONAL SLOT AT CORNERS

- NOTES:**
1. Round corners of acute angle sawcuts to prevent damage to conductors.
 2. Typical distance separating loops from edge to edge is 10' for Type A, B, D and E installation in single lane.

STATE OF CALIFORNIA
DEPARTMENT OF TRANSPORTATION

ELECTRICAL SYSTEMS (DETECTORS)

NO SCALE


RSP ES-5B DATED JULY 19, 2013 SUPERSEDES STANDARD PLAN ES-5B DATED MAY 20, 2011 - PAGE 449 OF THE STANDARD PLANS BOOK DATED 2010.

2010 REVISED STANDARD PLAN RSP ES-5B


Dist	COUNTY	ROUTE	POST MILES TOTAL PROJECT	SHEET No.	TOTAL SHEETS
10	SJ	4	0.074, 34.4/5.4 6.9/8.3	24	24

Theresa Gabriel
 REGISTERED ELECTRICAL ENGINEER
 July 19, 2013
 PLANS APPROVAL DATE
THE STATE OF CALIFORNIA OR ITS OFFICERS OR AGENTS SHALL NOT BE RESPONSIBLE FOR THE ACCURACY OR COMPLETENESS OF SCANNED COPIES OF THIS PLAN SHEET.


2010 REVISED STANDARD PLAN RSP ES-5D

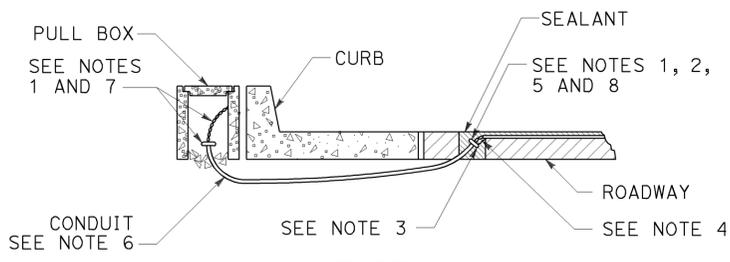


TYPE A
CURB TERMINATION DETAIL

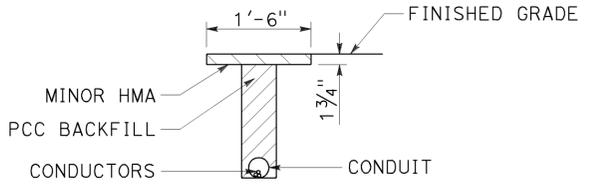


"T" TRENCH
DETAIL T

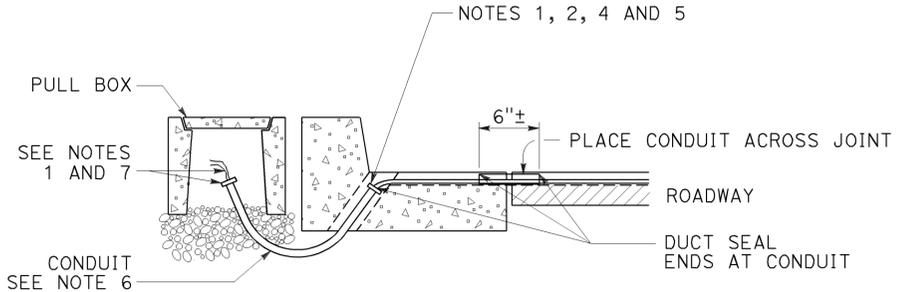

CROSS SECTION

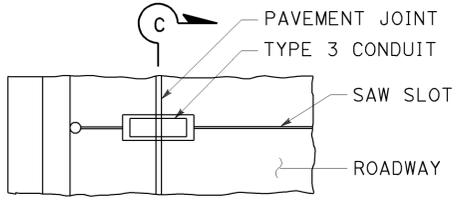


PLAN VIEW

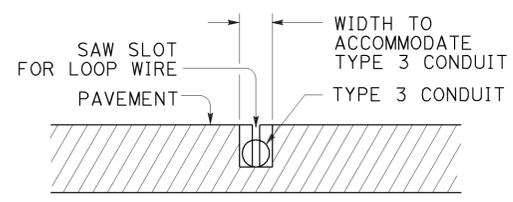


SECTION C-C


TYPE B
CURB TERMINATION DETAIL

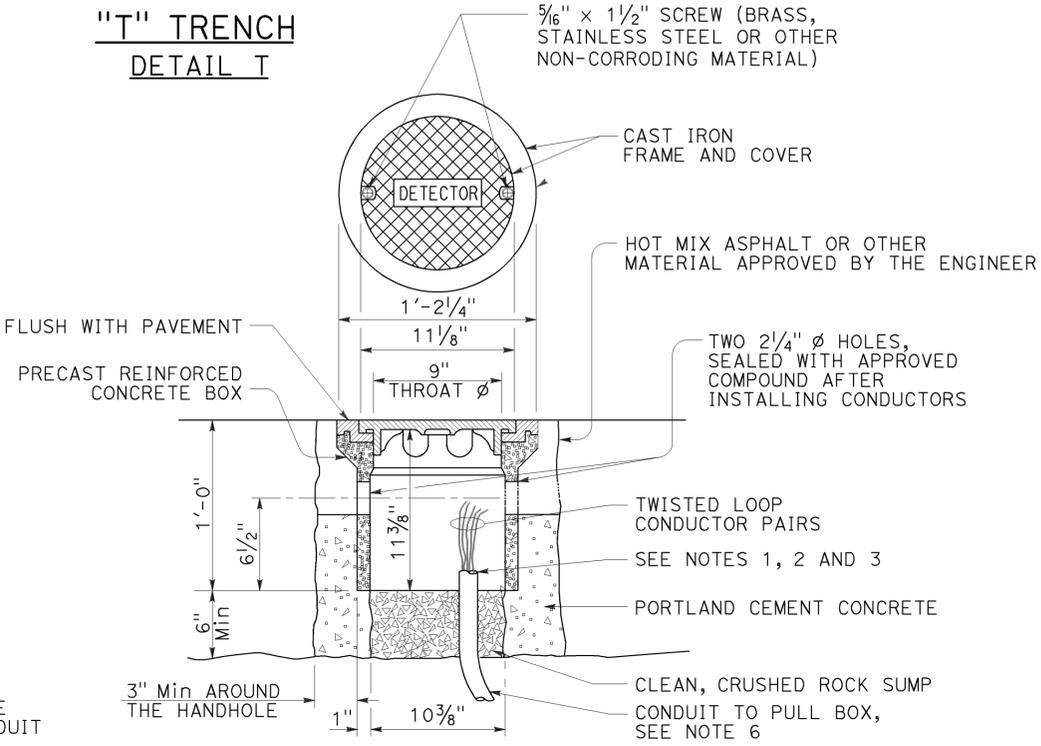


DETECTOR HANDHOLE DETAIL

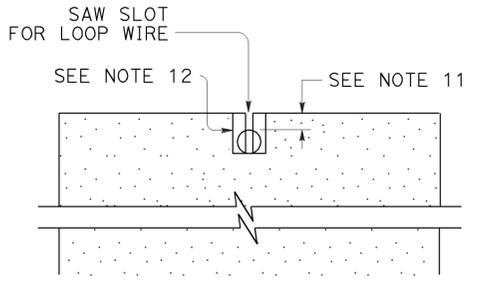


SECTION A-A

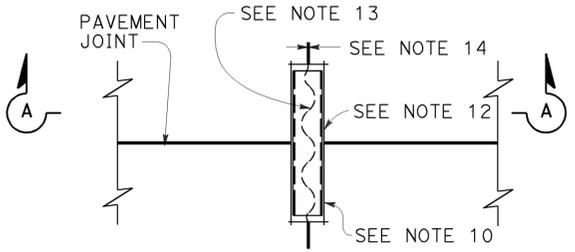


PLAN VIEW
TYPICAL LOOP LEAD-IN DETAIL
AT PAVEMENT JOINT

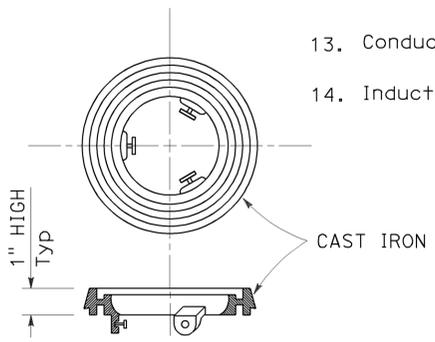

LOCKING GRADE RING

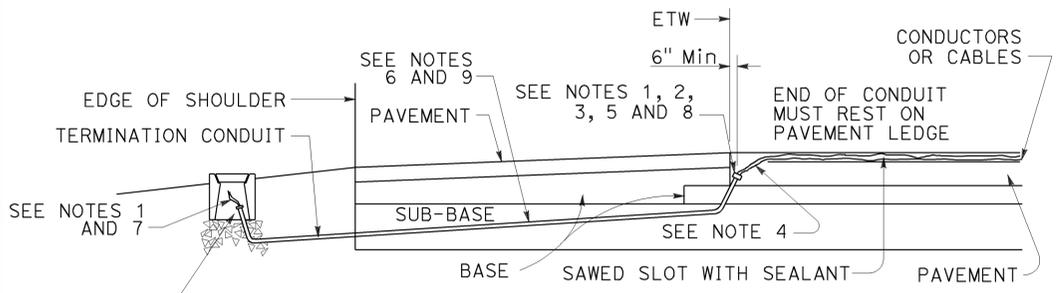

CROSS SECTION

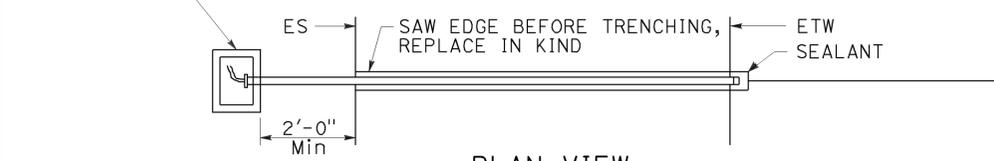

PLAN VIEW
SHOULDER TERMINATION DETAILS

NOTES:

- Bushing shall be used at end of conduit.
- Tape detector conductors or cables 3" each side of bushings.
- Install duct seal compound to each end of termination conduit before installing sealant.
- Round all sharp edges where detector conductors or cables have to pass.
- End of conduit shall be 3/8" below roadway surface.
- | | |
|-----------------|-----------------|
| Conduit size | Loop conductors |
| 1"C minimum | 1 to 2 pairs |
| 1 1/2"C minimum | 3 to 4 pairs |
| 2"C minimum | 5 or more pairs |
- Splice detector conductors or cables to detector lead-in-cable.
- Location of detector handhole when shown on plans.
- When the shoulder and traveled way are paved with the same material and there is no joint between them, the conduit shall extend only 2'-0" into the shoulder pavement.
- 3/4"C, Type 3 conduit 6" long minimum, plug both ends with duct compound to keep out sealant.
- 1/2" Minimum between top of conduit and pavement surface.
- Sawcut shall not exceed 1" in width and 1/8" longer than conduit to be installed.
- Conductors with 1/2" minimum slack inside conduit.
- Inductive loop detector saw slot.

STATE OF CALIFORNIA
DEPARTMENT OF TRANSPORTATION
ELECTRICAL SYSTEMS
(CURB TERMINATION
AND HANDHOLE)
NO SCALE

RSP ES-5D DATED JULY 19, 2013 SUPERSEDES STANDARD PLAN ES-5D
DATED MAY 20, 2011 - PAGE 451 OF THE STANDARD PLANS BOOK DATED 2010.

REVISED STANDARD PLAN RSP ES-5D